

CITY OF FLINT DEPARTMENT OF PUBLIC WORKS NORTHWEST PUMP STATION IMPROVEMENTS

Project Location:
Township of Flint
Section 4 of T7N, R6E,
Geographic Township of Flint
Genesee County, Michigan 48532




PROJECT NUMBER: SRF-5696-01


CITY OF FLINT OFFICIALS

SHELDON NEELEY ERIC MAYS MAURICE DAVIS SANTINO J. GUERRA KATE FIELDS JERRI WINFREY-CARTER HERBERT WINFREY MONICA GALLOWAY ALLAN GRIGGS EVA WORTHING	MAYOR CITY COUNCIL 1ST WARD CITY COUNCIL 2ND WARD CITY COUNCIL 3RD WARD CITY COUNCIL 4TH WARD CITY COUNCIL 5TH WARD CITY COUNCIL 6TH WARD CITY COUNCIL 7TH WARD CITY COUNCIL 8TH WARD CITY COUNCIL 9TH WARD
--	--

SHEET INDEX	
SHEET	DESCRIPTION
CS	Title Sheet
G-001	Legend & Project Notes
G-002	Sewer District Map and Design Calculations
V-101	Existing Pump Station Plan Views and Section View
V-102	Existing Photos
V-103	Existing Photos
V-104	Existing Photos
V-105	Existing Photos
C-101	Demolition Plan
C-102	Proposed Pump Station Plan Views
C-103	Proposed Pump Station Section Views A-A and B-B
C-104	Proposed Pump Station Section View C-C
C-105	Proposed Sluice Gate Plans
C-106	Proposed Forcemain Work
C-107	Proposed Forcemain Work
E-101	Electrical Design
E-102	Electrical Design
E-103	Electrical Design
E-104	Electrical Design
E-105	Electrical Design
E-106	Electrical Design
E-107	Electrical Design
E-108	Electrical Design

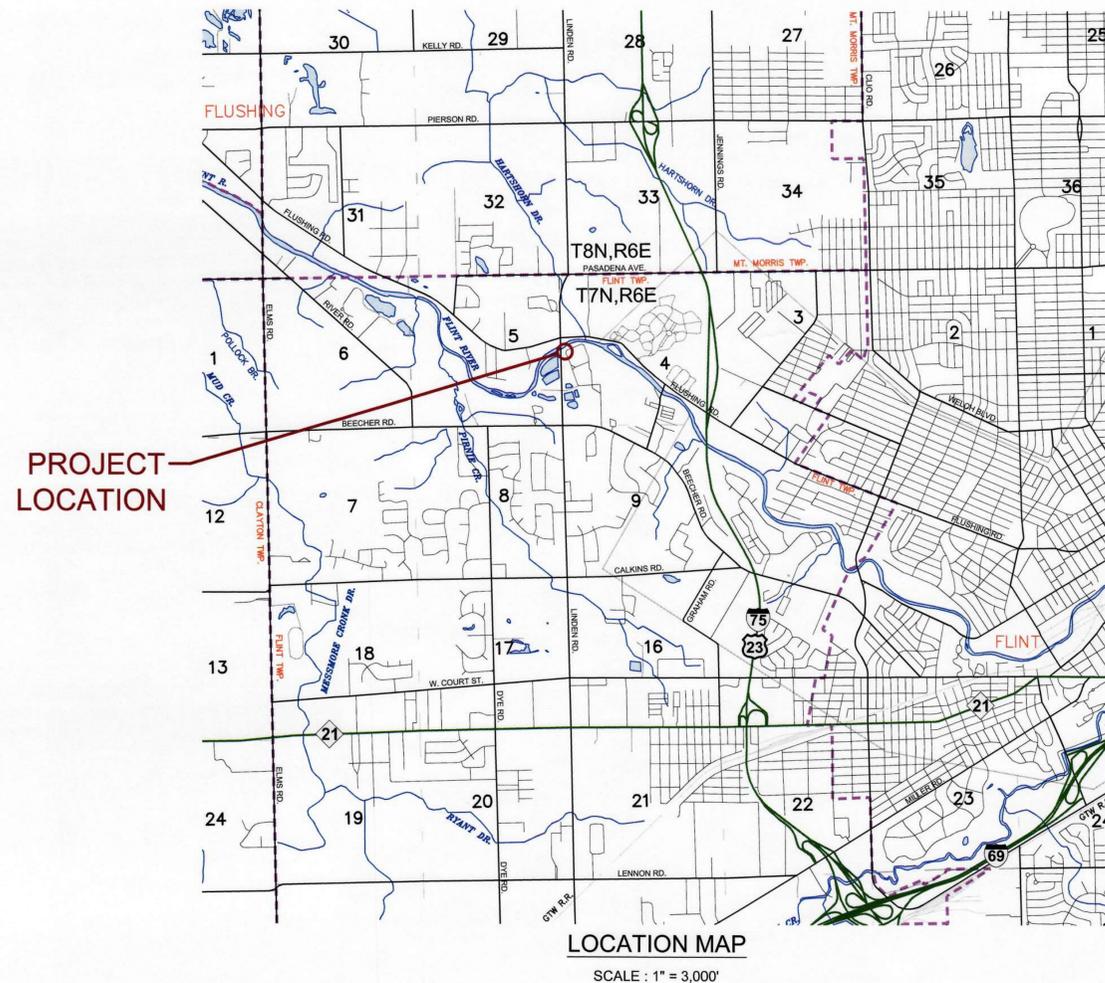

APPROVED BY THE CITY OF FLINT				
_____ DIRECTOR OF DEPARTMENT OF PUBLIC WORKS				
PROJECT DESCRIPTION: NORTHWEST PUMPING STATION IMPROVEMENTS				
PREPARED UNDER THE SUPERVISION OF				
<table border="0" style="width: 100%;"> <tr> <td style="width: 50%;">GREG J. GUCWA REGISTERED PROFESSIONAL ENGINEER</td> <td style="width: 50%;">026553 REGISTRATION NO.</td> </tr> <tr> <td colspan="2">DLZ COMPANY ORGANIZATION</td> </tr> </table>	GREG J. GUCWA REGISTERED PROFESSIONAL ENGINEER	026553 REGISTRATION NO.	DLZ COMPANY ORGANIZATION	
GREG J. GUCWA REGISTERED PROFESSIONAL ENGINEER	026553 REGISTRATION NO.			
DLZ COMPANY ORGANIZATION				

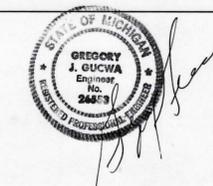

GENERAL NOTES

THE CONTRACTOR SHALL CALL "MISS DIG" (1-800-482-7171) THREE WORKING DAYS, EXCEPT SATURDAY, SUNDAY, AND HOLIDAYS PRIOR TO COMMENCEMENT OF ANY WORK.

ALL UTILITIES SHOWN ARE APPROXIMATE LOCATIONS DERIVED FROM ACTUAL MEASUREMENTS AND AVAILABLE RECORDS. THEY SHOULD NOT BE INTERPRETED TO BE THE EXACT LOCATION NOR SHOULD IT BE ASSUMED THAT THEY ARE THE ONLY UTILITIES IN THE AREA.

THE IMPROVEMENTS COVERED BY THESE PLANS SHALL BE DONE IN ACCORDANCE WITH THE CITY OF FLINT CODE OF ORDINANCES.



INNOVATIVE IDEAS
EXCEPTIONAL DESIGN
UNMATCHED CLIENT SERVICE

PROJECT No.
1849-0706-00
SHEET 1 OF 16

DATE ISSUED: 2/14/2020
DATE FINAL: 3/2/2020

Layout: G-002
 RUT DATE: 2/14/2020 1:51:27 PM
 SAVE DATE: 2/11/2020 4:11:59 PM
 BRENDAN WARBEL X:\Projects\Waterfor18500\18706_Sewer_District_Map_and_Design_Calc.dwg
 City of Flint Pump Station Rehabilitation\18706_Sewer_District_Map_and_Design_Calc.dwg


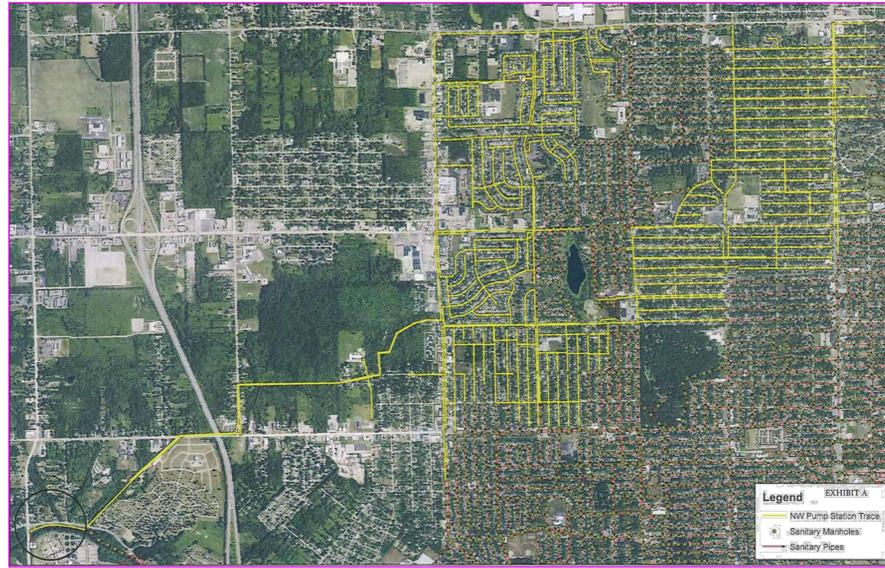



EXHIBIT C

CITY OF FLINT NORTHWEST PUMP STATION
24 hr/24yr flow model results


25 Year 24 Hour Flow to NWPS		25 Year 24 Hour Flow to NWPS		25 Year 24 Hour Flow to NWPS		25 Year 24 Hour Flow to NWPS		25 Year 24 Hour Flow to NWPS	
Flow (cfs)	Flow (cfs)								
6/23/2017 0:00	1.183	6/23/2017 11:00	2.201	6/23/2017 21:00	4.132	6/24/2017 8:55	1.996	6/24/2017 19:00	1.503
6/23/2017 0:15	1.182	6/23/2017 11:15	2.247	6/23/2017 21:15	4.07	6/24/2017 9:10	1.904	6/24/2017 19:15	1.495
6/23/2017 0:30	1.181	6/23/2017 11:30	2.304	6/23/2017 21:30	4.013	6/24/2017 9:25	1.879	6/24/2017 19:30	1.486
6/23/2017 0:45	1.18	6/23/2017 11:45	2.367	6/23/2017 21:45	3.959	6/24/2017 9:40	1.844	6/24/2017 19:45	1.48
6/23/2017 1:00	1.18	6/23/2017 12:00	2.44	6/23/2017 22:00	3.906	6/24/2017 9:55	1.816	6/24/2017 20:00	1.472
6/23/2017 1:15	1.179	6/23/2017 12:15	2.522	6/23/2017 22:15	3.855	6/24/2017 10:10	1.789	6/24/2017 20:15	1.469
6/23/2017 1:30	1.18	6/23/2017 12:30	2.621	6/23/2017 22:30	3.804	6/24/2017 10:25	1.764	6/24/2017 20:30	1.465
6/23/2017 1:45	1.18	6/23/2017 12:45	2.736	6/23/2017 22:45	3.752	6/24/2017 10:40	1.74	6/24/2017 20:45	1.465
6/23/2017 2:00	1.181	6/23/2017 13:00	2.873	6/23/2017 23:00	3.701	6/24/2017 10:55	1.718	6/24/2017 21:00	1.469
6/23/2017 2:15	1.183	6/23/2017 13:15	3.038	6/23/2017 23:15	3.659	6/24/2017 11:10	1.698	6/24/2017 21:15	1.48
6/23/2017 2:30	1.189	6/23/2017 13:30	3.229	6/23/2017 23:30	3.628	6/24/2017 11:25	1.686	6/24/2017 21:30	1.42
6/23/2017 2:45	1.199	6/23/2017 13:45	3.445	6/23/2017 23:45	3.607	6/24/2017 11:40	1.68	6/24/2017 21:45	1.411
6/23/2017 3:00	1.217	6/23/2017 14:00	3.688	6/23/2017 24:00	3.595	6/24/2017 11:55	1.668	6/24/2017 22:00	1.404
6/23/2017 3:15	1.24	6/23/2017 14:15	3.958	6/23/2017 24:15	3.593	6/24/2017 12:10	1.657	6/24/2017 22:15	1.396
6/23/2017 3:30	1.268	6/23/2017 14:30	4.254	6/23/2017 24:30	3.591	6/24/2017 12:25	1.646	6/24/2017 22:30	1.389
6/23/2017 3:45	1.296	6/23/2017 14:45	4.575	6/23/2017 24:45	3.59	6/24/2017 12:40	1.635	6/24/2017 22:45	1.382
6/23/2017 4:00	1.33	6/23/2017 15:00	4.929	6/23/2017 25:00	3.589	6/24/2017 12:55	1.624	6/24/2017 23:00	1.376
6/23/2017 4:15	1.365	6/23/2017 15:15	5.314	6/23/2017 25:15	3.588	6/24/2017 13:10	1.613	6/24/2017 23:15	1.37
6/23/2017 4:30	1.402	6/23/2017 15:30	5.729	6/23/2017 25:30	3.587	6/24/2017 13:25	1.602	6/24/2017 23:30	1.364
6/23/2017 4:45	1.44	6/23/2017 15:45	6.174	6/23/2017 25:45	3.586	6/24/2017 13:40	1.591	6/24/2017 23:45	1.357
6/23/2017 5:00	1.478	6/23/2017 16:00	6.648	6/23/2017 26:00	3.585	6/24/2017 13:55	1.58	6/25/2017 0:00	1.352
6/23/2017 5:15	1.515	6/23/2017 16:15	7.151	6/23/2017 26:15	3.584	6/24/2017 14:10	1.569		
6/23/2017 5:30	1.551	6/23/2017 16:30	7.684	6/23/2017 26:30	3.583	6/24/2017 14:25	1.558		
6/23/2017 5:45	1.588	6/23/2017 16:45	8.247	6/23/2017 26:45	3.582	6/24/2017 14:40	1.547		
6/23/2017 6:00	1.628	6/23/2017 17:00	8.84	6/23/2017 27:00	3.581	6/24/2017 14:55	1.536		
6/23/2017 6:15	1.65	6/23/2017 17:15	9.464	6/23/2017 27:15	3.58	6/24/2017 15:10	1.525		
6/23/2017 6:30	1.679	6/23/2017 17:30	10.118	6/23/2017 27:30	3.579	6/24/2017 15:25	1.514		
6/23/2017 6:45	1.708	6/23/2017 17:45	10.801	6/23/2017 27:45	3.578	6/24/2017 15:40	1.503		
6/23/2017 7:00	1.736	6/23/2017 18:00	11.514	6/23/2017 28:00	3.577	6/24/2017 15:55	1.492		
6/23/2017 7:15	1.764	6/23/2017 18:15	12.257	6/23/2017 28:15	3.576	6/24/2017 16:10	1.481		
6/23/2017 7:30	1.791	6/23/2017 18:30	13.03	6/23/2017 28:30	3.575	6/24/2017 16:25	1.47		
6/23/2017 7:45	1.818	6/23/2017 18:45	13.833	6/23/2017 28:45	3.574	6/24/2017 16:40	1.459		
6/23/2017 8:00	1.846	6/23/2017 19:00	14.666	6/23/2017 29:00	3.573	6/24/2017 16:55	1.448		
6/23/2017 8:15	1.879	6/23/2017 19:15	15.53	6/23/2017 29:15	3.572	6/24/2017 17:10	1.437		
6/23/2017 8:30	1.902	6/23/2017 19:30	16.433	6/23/2017 29:30	3.571	6/24/2017 17:25	1.426		
6/23/2017 8:45	1.93	6/23/2017 19:45	17.366	6/23/2017 29:45	3.57	6/24/2017 17:40	1.415		
6/23/2017 9:00	1.961	6/23/2017 20:00	18.33	6/23/2017 30:00	3.569	6/24/2017 17:55	1.404		
6/23/2017 9:15	1.991	6/23/2017 20:15	19.333	6/23/2017 30:15	3.568	6/24/2017 18:10	1.393		
6/23/2017 9:30	2.023	6/23/2017 20:30	20.366	6/23/2017 30:30	3.567	6/24/2017 18:25	1.382		
6/23/2017 9:45	2.055	6/23/2017 20:45	21.433	6/23/2017 30:45	3.566	6/24/2017 18:40	1.371		
6/23/2017 10:00	2.088	6/23/2017 21:00	22.533	6/23/2017 31:00	3.565	6/24/2017 18:55	1.36		
6/23/2017 10:15	2.123	6/23/2017 21:15	23.666	6/23/2017 31:15	3.564	6/24/2017 19:10	1.349		
6/23/2017 10:30	2.16	6/23/2017 21:30	24.833	6/23/2017 31:30	3.563	6/24/2017 19:25	1.338		

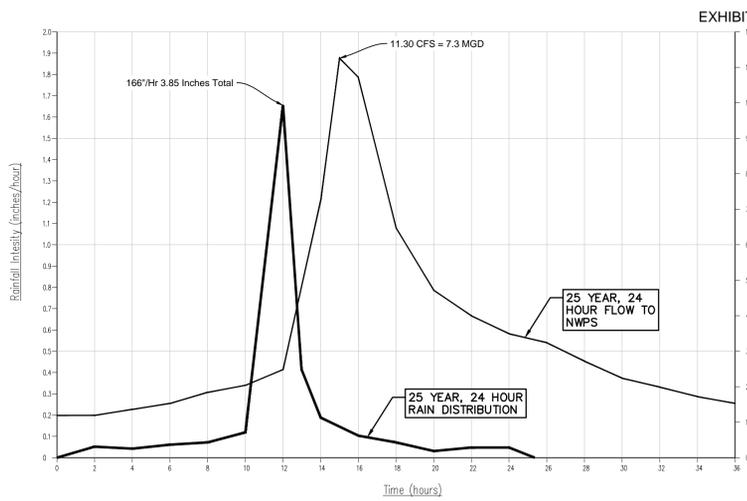

SCALE: VERT. -
HORIZ. 1" = 4"

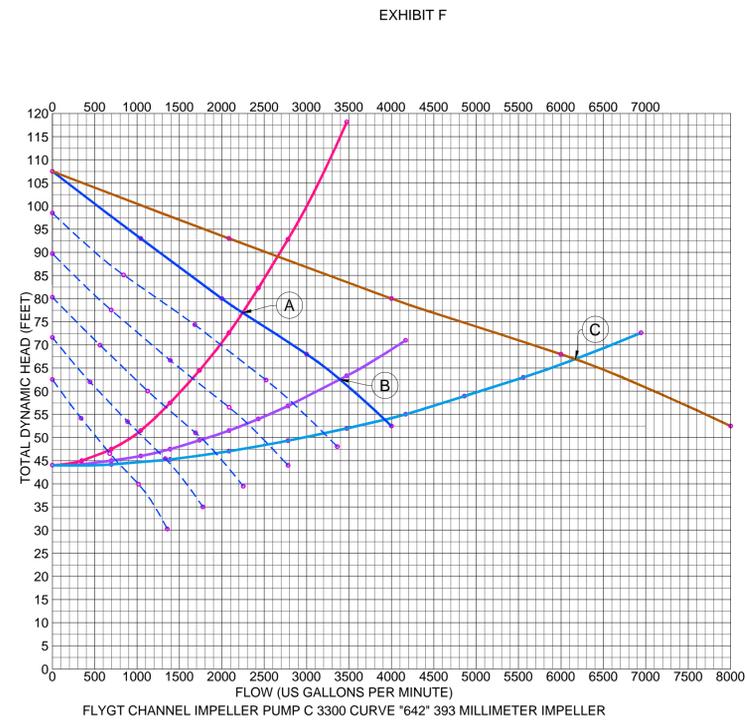

- LEGEND**
- SYSTEM CURVE 14" HDPE F.M. - 1 PUMP
 - SYSTEM CURVE 24" DIP F.M. - 1 PUMP
 - SYSTEM CURVE 24" DIP F.M. - 2 PUMPS
 - 60 HZ 1185 RPM - 1 PUMP
 - 60 HZ 1185 RPM - 2 PUMPS
- (A)** 2272 GPM - 3.27 MGD
77 TDH 1 PUMP ON DISCHARGE THROUGH 14" HDPE F.M.
- (B)** 3421 GPM - 4.9 MGD
62 TDH 1 PUMP ON DISCHARGE THROUGH 24" DIP F.M.
- (C)** 6000 GPM - 8.6 MGD
68 TDH 2 PUMPS ON DISCHARGE THROUGH 24" DIP F.M.
- 1** 1 PUMP TO 14" HDPE F.M. & 1 PUMP TO 24" DIP F.M. = 3.27 MGD + 4.9 MGD = 8.17 MGD
- 2** 2 PUMPS TO 24" DIP F.M. = 8.6 MGD
- STATION CAPACITY:
A = 3.27 MGD
B = 4.90 MGD
A+B = 8.17 MGD
A+C = 11.87 MGD

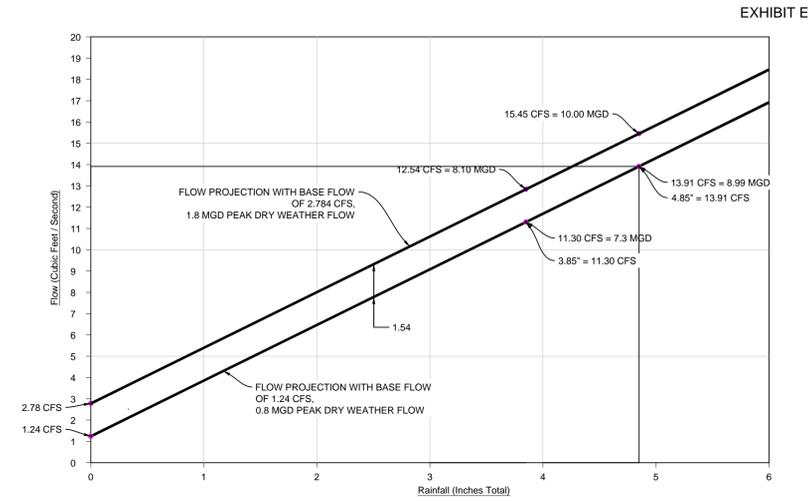

811
3 FULL WORKING DAYS
BEFORE YOU DIG CALL
 Know what's below
 Call before you dig
 MISS DIG System, Inc.
 1-800-482-7171 www.missdig.net

DLZ

ARCHITECTURE • ENGINEERING • PLANNING
SURVEYING • CONSTRUCTION SERVICES

INNOVATIVE IDEAS
EXCEPTIONAL DESIGN
UNMATCHED CLIENT SERVICE

WARNING
 UTILITY LOCATIONS ARE NOT CONFIRMED. THOSE SHOWN WERE OBTAINED FROM MISS DIG SYSTEM, INC. PRIOR TO BEGINNING WORK. THE CONTRACTOR SHALL VERIFY ALL UTILITY LOCATIONS AND HAVE WORK AREA STAKED AND HE SHALL PROTECT OR HAVE RELOCATED, AS NOTED IN THE SPECIFICATIONS. ALL INTERFERENCE WITH CONSTRUCTION

City of Flint
 1101 S. Saginaw Street
 Flint, Michigan 48502

Northwest Pump Station Improvements
 Sewer District Map and Design Calcs


NOT TO SCALE

MARK	ISSUED FOR	DATE


DRAWN BY: DLZ
 DESIGN BY: GJG
 CHECKED BY: GJG

DLZ JOB NUMBER: 1849-0706-00


SHEET NO. **G-002**

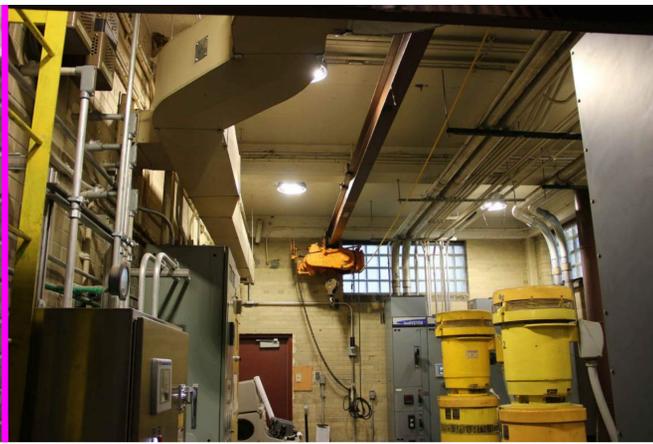

FLOOR ELEV 703.00 OUTSIDE
LOOKING SOUTHWEST

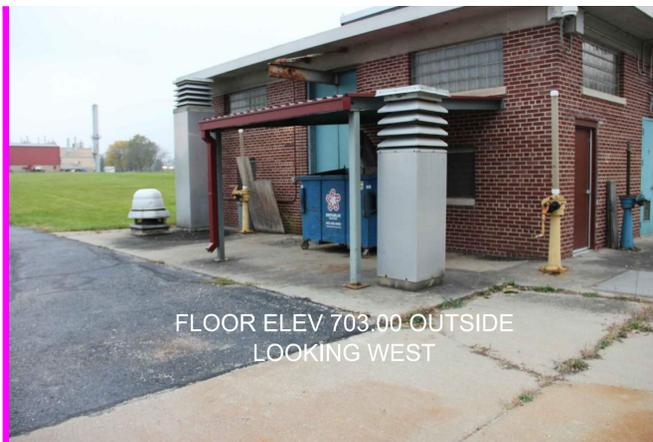

FLOOR ELEV 703.00 OUTSIDE
LOOKING WEST

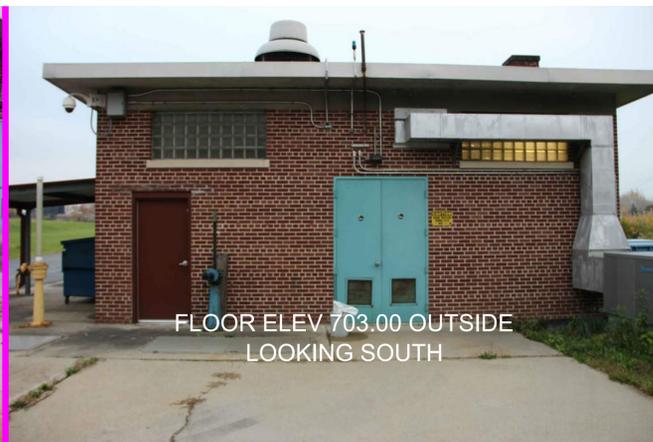


FLOOR ELEV 703.00 OUTSIDE
LOOKING SOUTH




FLOOR ELEV 703.00 OUTSIDE
LOOKING ---




FLOOR ELEV 703.00 OUTSIDE
LOOKING ---

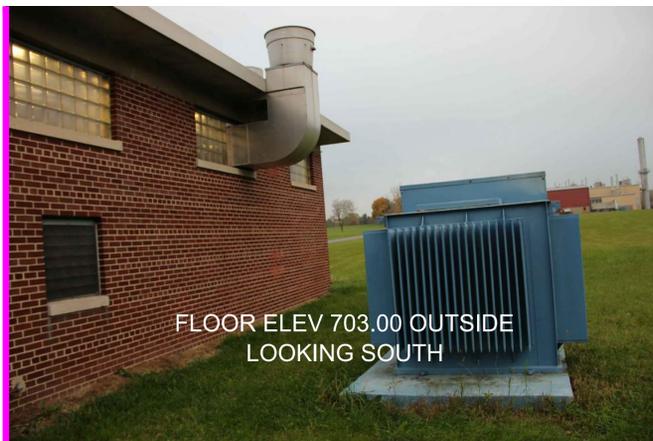

FLOOR ELEV 703.00 OUTSIDE
LOOKING SOUTH

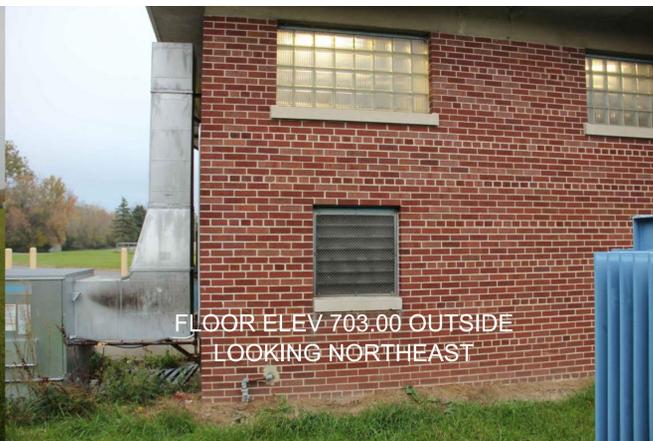


FLOOR ELEV 703.00 OUTSIDE
LOOKING NORTHEAST

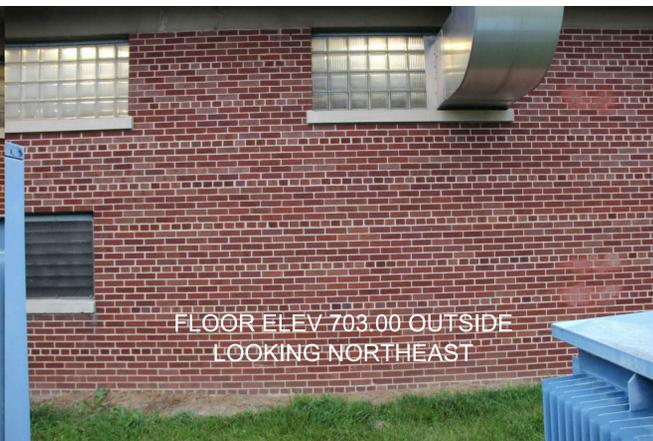

FLOOR ELEV 703.00 OUTSIDE
LOOKING NORTHEAST



FLOOR ELEV 703.00 OUTSIDE
LOOKING NORTHEAST

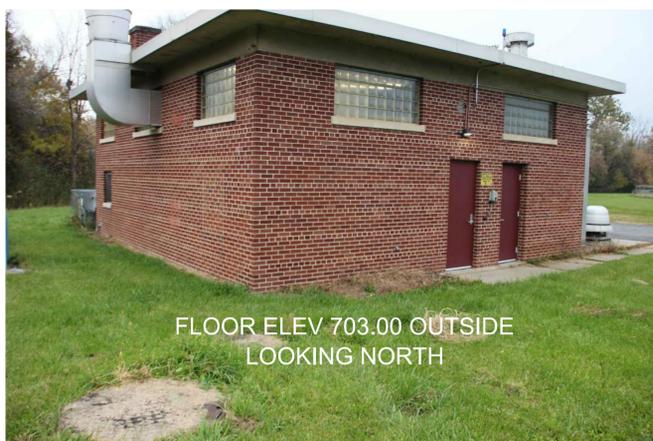

FLOOR ELEV 703.00 OUTSIDE
LOOKING NORTH



FLOOR ELEV 703.00 OUTSIDE
LOOKING NORTHWEST



FLOOR ELEV 703.00 OUTSIDE
LOOKING WEST



FLOOR ELEV 703.00 OUTSIDE
LOOKING SOUTHWEST

811
3 FULL WORKING DAYS
BEFORE YOU DIG CALL
Know what's below
Call before you dig
MISS DIG System, Inc.
1-800-482-7171 www.missdig.net



INNOVATIVE IDEAS
EXCEPTIONAL DESIGN
UNMATCHED CLIENT SERVICE

WARNING
UTILITY LOCATIONS ARE NOT
CONFIRMED. THOSE SHOWN
ON THESE PLANS ARE THE
UTILITY OWNERS OR PLANS
THREE FULL WORKING DAYS
BEFORE YOU DIG CALL
THE CONTRACTOR SHALL
NOTIFY UTILITY OWNERS TO
HAVE AN AREA STAKED
AND RELOCATED, AS NOTED
IN THE SPECIFICATIONS. ALL
INTERFERENCE WITH
CONSTRUCTION



City of Flint
1101 S. Saginaw Street
Flint, Michigan 48502

Northwest Pump Station Improvements
Existing Photos

NOT TO SCALE

MARK	ISSUED FOR	DATE
-	EAGLE SUBMITTAL	2/14/2020
-	-	-
-	-	-
-	-	-
-	-	-
-	-	-
-	-	-
-	-	-
-	-	-

DRAWN BY: DLZ
DESIGN BY: GJG
CHECKED BY: GJG


DLZ JOB NUMBER: 1849-0706-00

SHEET NO.

V-105

Layout = V-05
 RUT DATE: 2/14/2020 1:52:34 PM
 SHE DATE: 2/14/2020 11:42:27 PM
 BRENDAN WUBBEL X:\Projects\WaterFor18500\18706_City of Flint Pump Station Rehabilitation\18706_Existing Conditions Photos.dwg

Layout = C-101
 PLOT DATE: 2/14/2020 1:52:40 PM
 SHE DATE: 2/14/2020 1:20:02 PM
 BRENDAN HIRBEL X:\Projects\Waterford\18500\18206 City of Flint Pump Station Remodel.dwg\18706 ELEVATIONS & SECTIONS.dwg

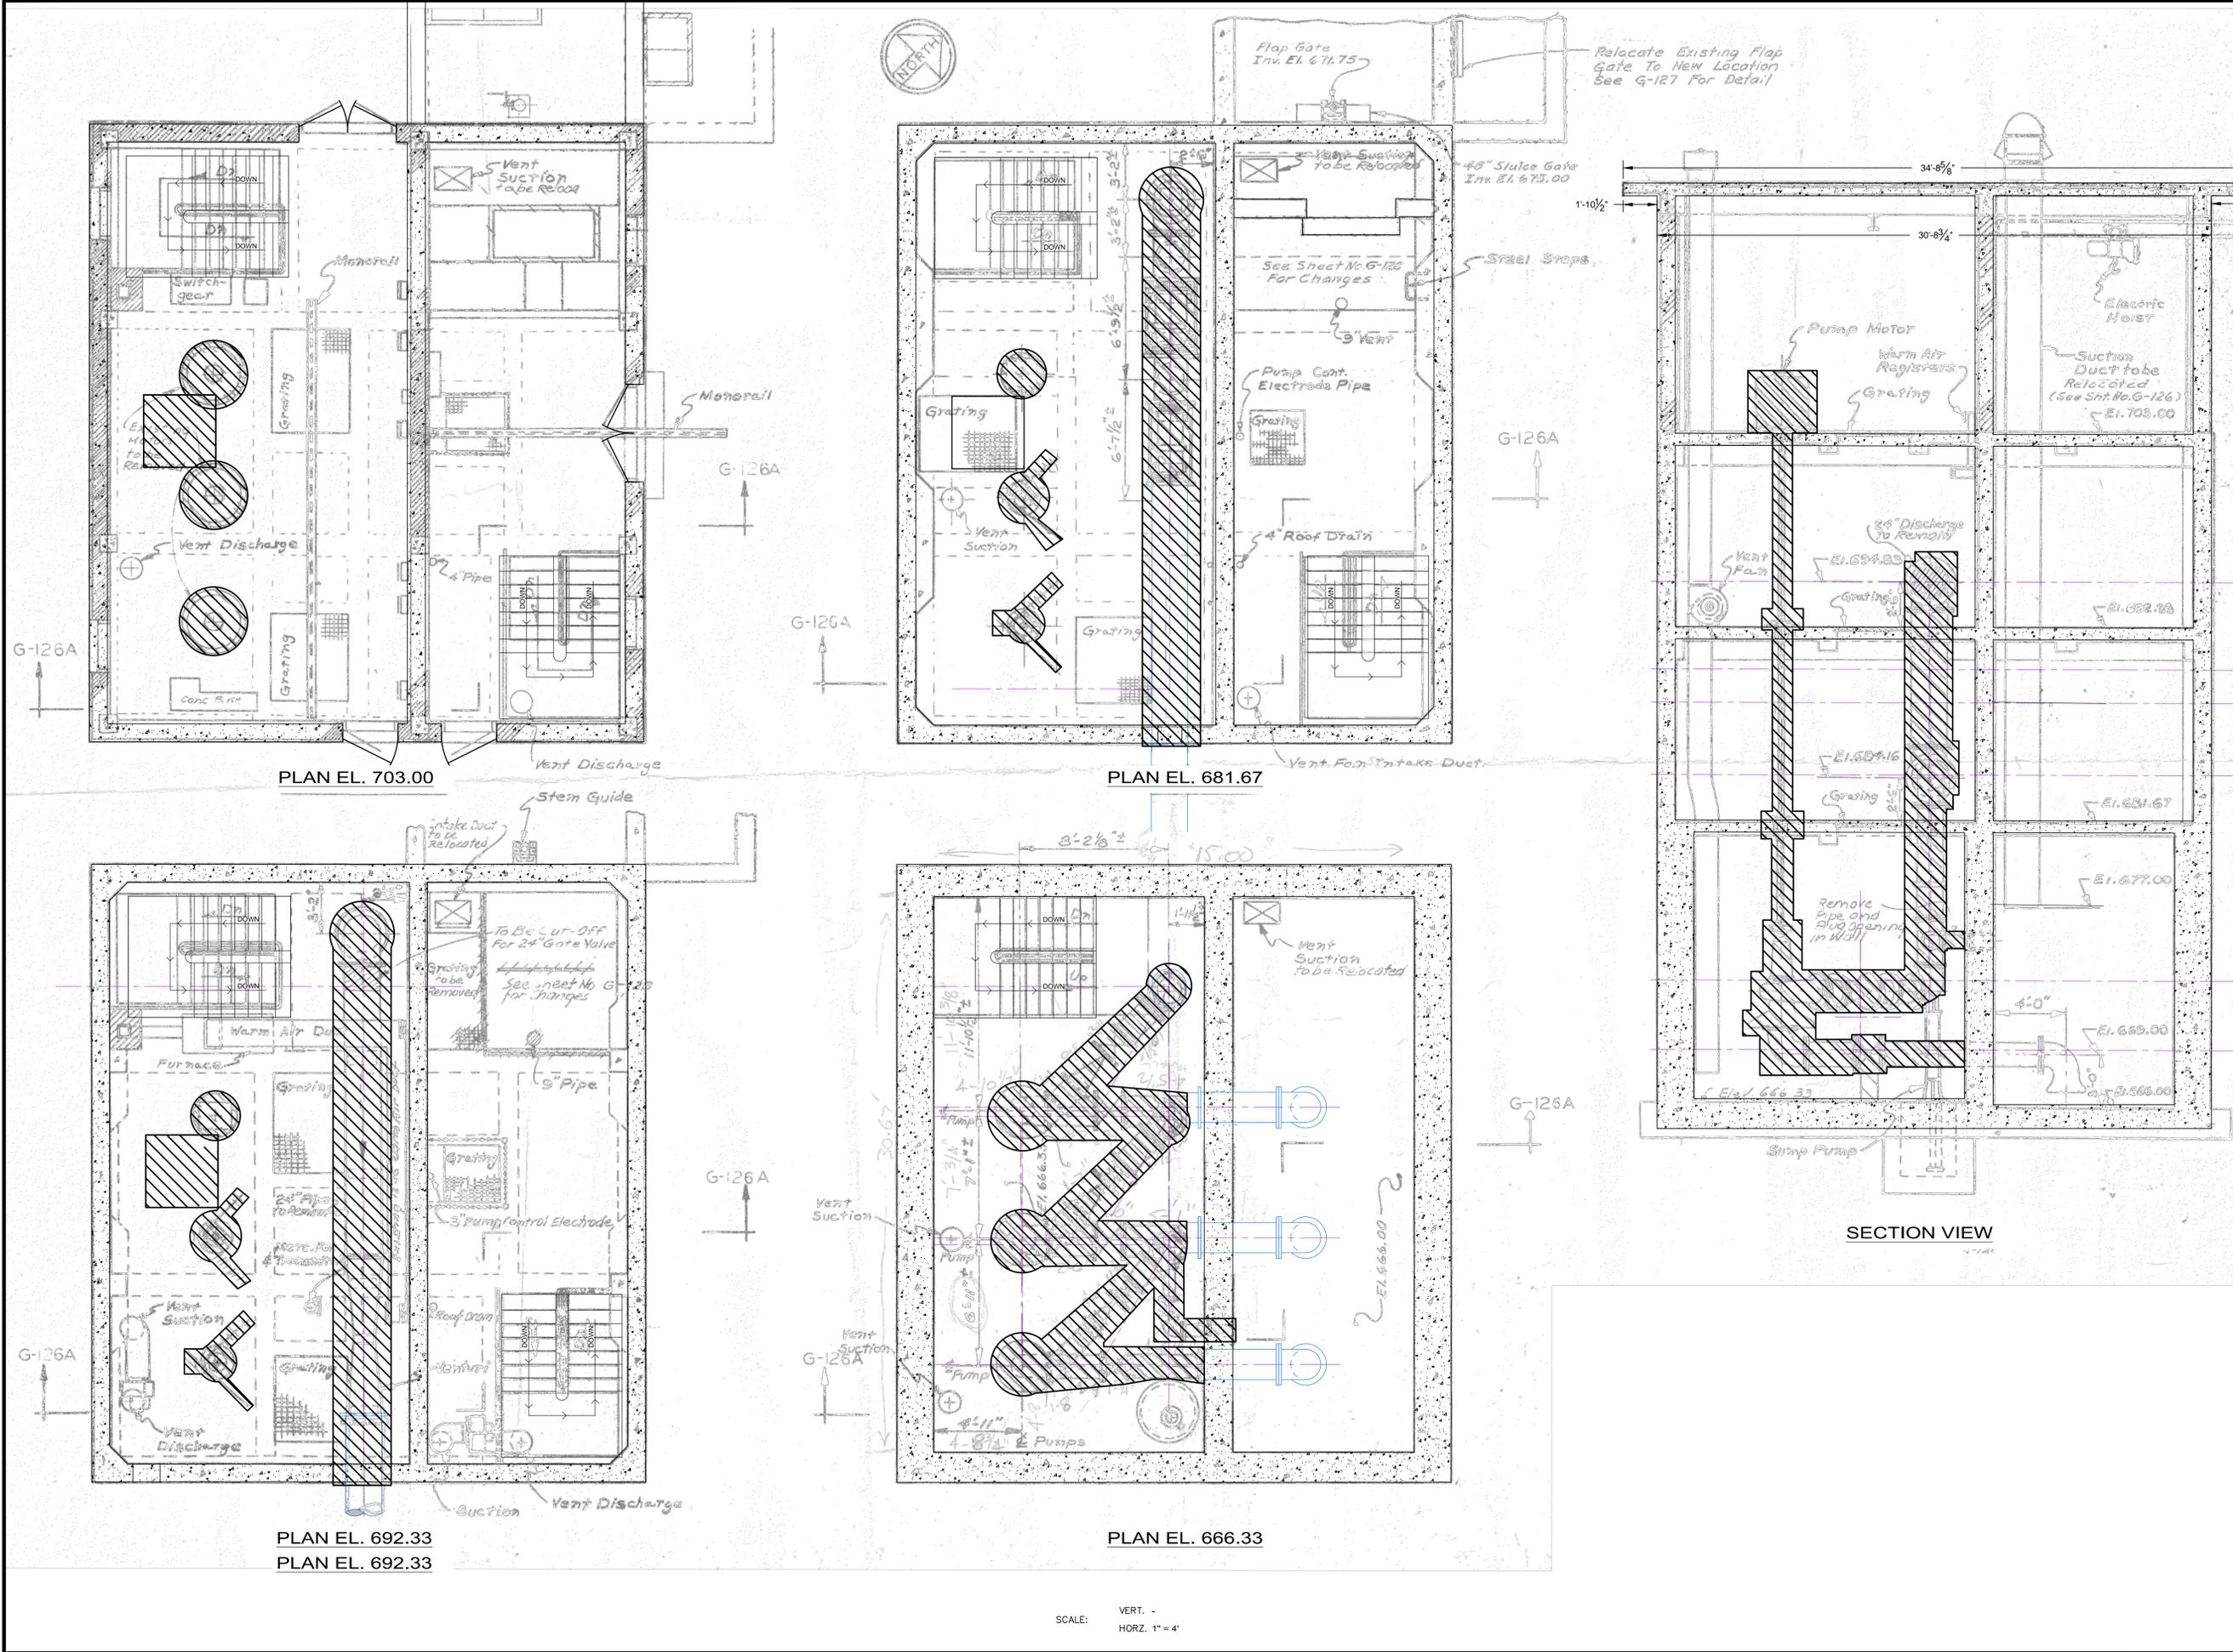

Know what's below
811 3 FULL WORKING DAYS BEFORE YOU DIG CALL
 MISS DIG System, Inc.
 1-800-482-7171 www.missdig.net

DLZ
 ARCHITECTURE • ENGINEERING • PLANNING
 SURVEYING • CONSTRUCTION SERVICES

INNOVATIVE IDEAS
 EXCEPTIONAL DESIGN
 UNMATCHED CLIENT SERVICE

WARNING
 UTILITY LOCATIONS ARE NOT CONFIRMED. THOSE SHOWN WERE OBTAINED FROM FIELD SURVEY. THE CONTRACTOR SHALL VERIFY ALL UTILITY LOCATIONS PRIOR TO BEGINNING WORK. THE CONTRACTOR SHALL HAVE WORK AREA STAKED AND HE SHALL PROTECT OR HAVE RELOCATED, AS NOTED IN THE SPECIFICATIONS. ALL INTERFERENCE WITH CONSTRUCTION



City of Flint
 1101 S. Saginaw Street
 Flint, Michigan 48502

Northwest Pump Station Improvements
 Demolition Plan

SCALE
 0 4 8

MARK	ISSUED FOR	DATE
-	EAGLE SUBMITTAL	2/14/2020
-		
-		
-		
-		
-		
-		
-		
-		


DRAWN BY: DLZ
 DESIGN BY: GJG
 CHECKED BY: GJG

DLZ JOB NUMBER: 1849-0706-00


SHEET NO.
C-101

SCALE:
 VERT. -
 HORZ. 1" = 4'


Layout = C-102
 ROOT DATE = 2/14/2020 1:52:43 PM
 SHE DATE = 2/14/2020 1:20:02 PM
 BRENDAN_HRBEEL_X:\Projects\Waterford\18500\18206_City of Flint Pump Station Rehab.dwg\18706_ELEVATIONS & SECTIONS.dwg

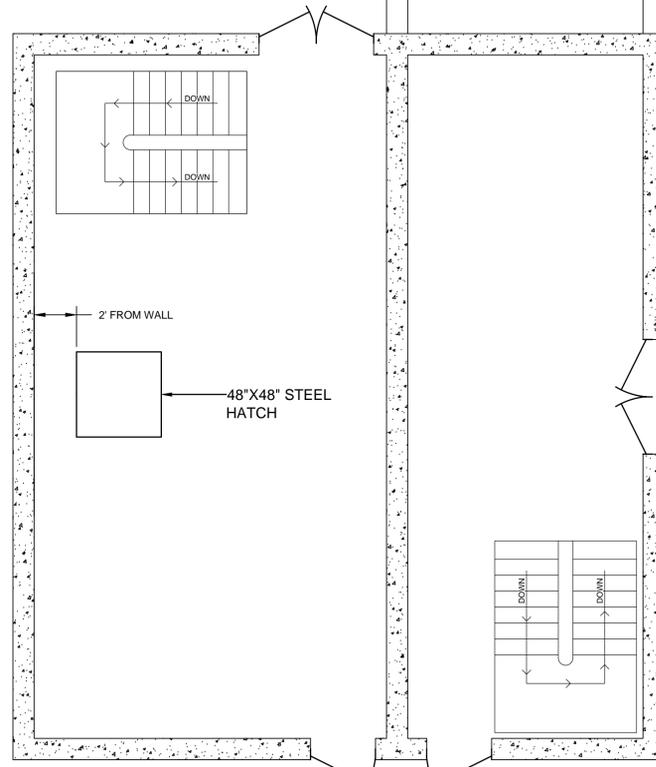

PLAN EL. 703.00

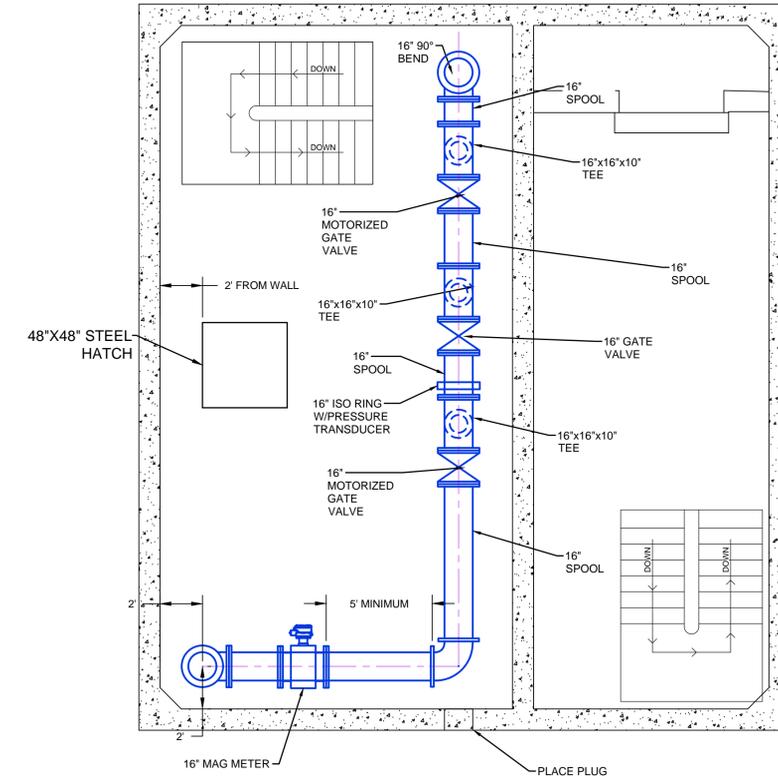


PLAN EL. 666.33

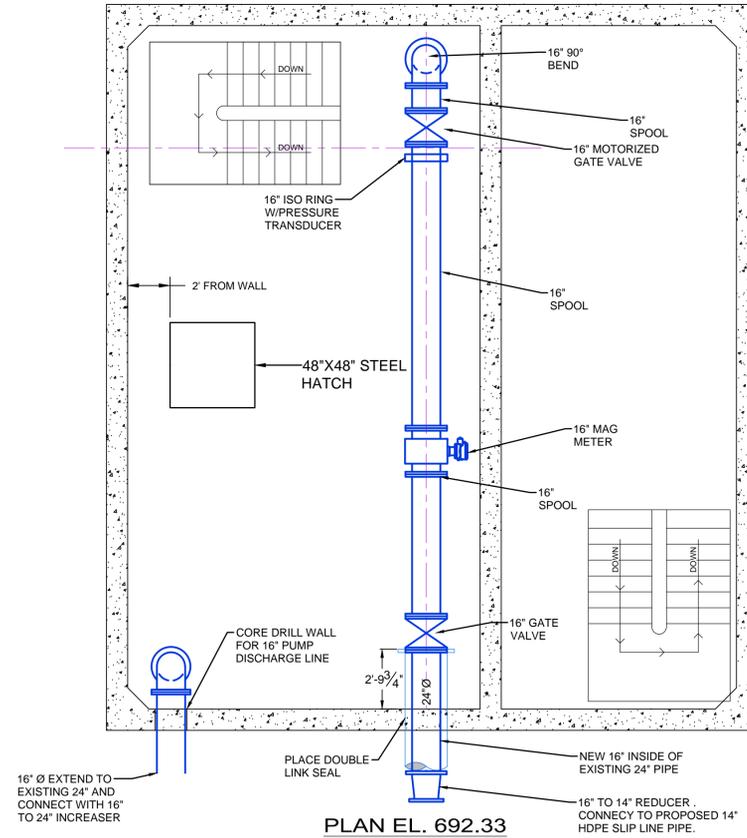

PLAN EL. 692.33

SCALE: VERT. -
 HORZ. 1" = 4'

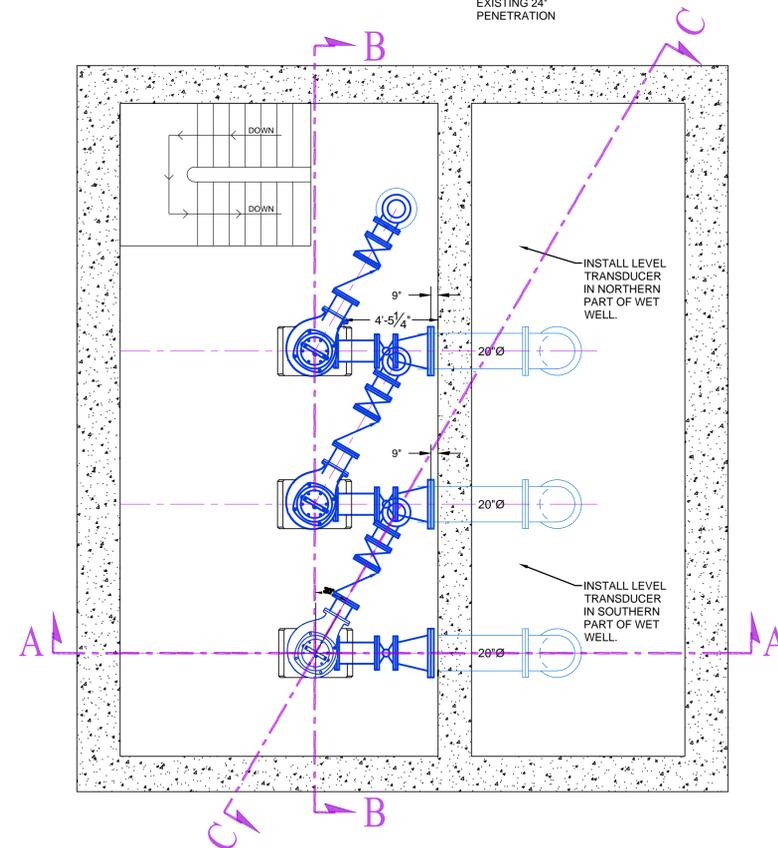

PLAN EL. 666.33


1'-11"

WARNING
 UTILITY LOCATIONS ARE NOT CONFIRMED. THOSE SHOWN WERE OBTAINED FROM THE CITY OF FLINT RECORDS. PRIOR TO BEGINNING WORK, THE CONTRACTOR SHALL VERIFY THE LOCATION AND DEPTH OF ALL UTILITIES AND HE SHALL PROTECT OR HAVE RELOCATED, AS NOTED IN THE SPECIFICATIONS. ALL INTERFERENCE WITH CONSTRUCTION



City of Flint
 1101 S. Saginaw Street
 Flint, Michigan 48502

Northwest Pump Station Improvements
 Proposed Pump Station Plan Views

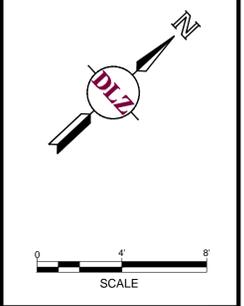

MARK	ISSUED FOR	DATE
-	EAGLE SUBMITTAL	2/14/2020
-		
-		
-		
-		
-		
-		
-		
-		

DRAWN BY: DLZ
 DESIGN BY: GJG
 CHECKED BY: GJG

DLZ JOB NUMBER: 1849-0706-00

SHEET NO.

C-102


811 Know what's below
 3 FULL WORKING DAYS BEFORE YOU DIG CALL
 MISS DIG System, Inc.
 1-800-482-7171 www.missdig.net

DLZ
 ARCHITECTURE • ENGINEERING • PLANNING
 SURVEYING • CONSTRUCTION SERVICES

INNOVATIVE IDEAS
 EXCEPTIONAL DESIGN
 UNMATCHED CLIENT SERVICE

Layout = C-103
 RPT DATE: 2/14/2020 1:52:48 PM
 SHE DATE: 2/14/2020 1:20:02 PM
 BRENDAN HROBEL X:\Projects\Waterford\18500\18500-City of Flint Pump Station Rehab.dwg\18706 ELEVATIONS & SECTIONS.dwg

TYPICAL CONCRETE PIPE SUPPORT

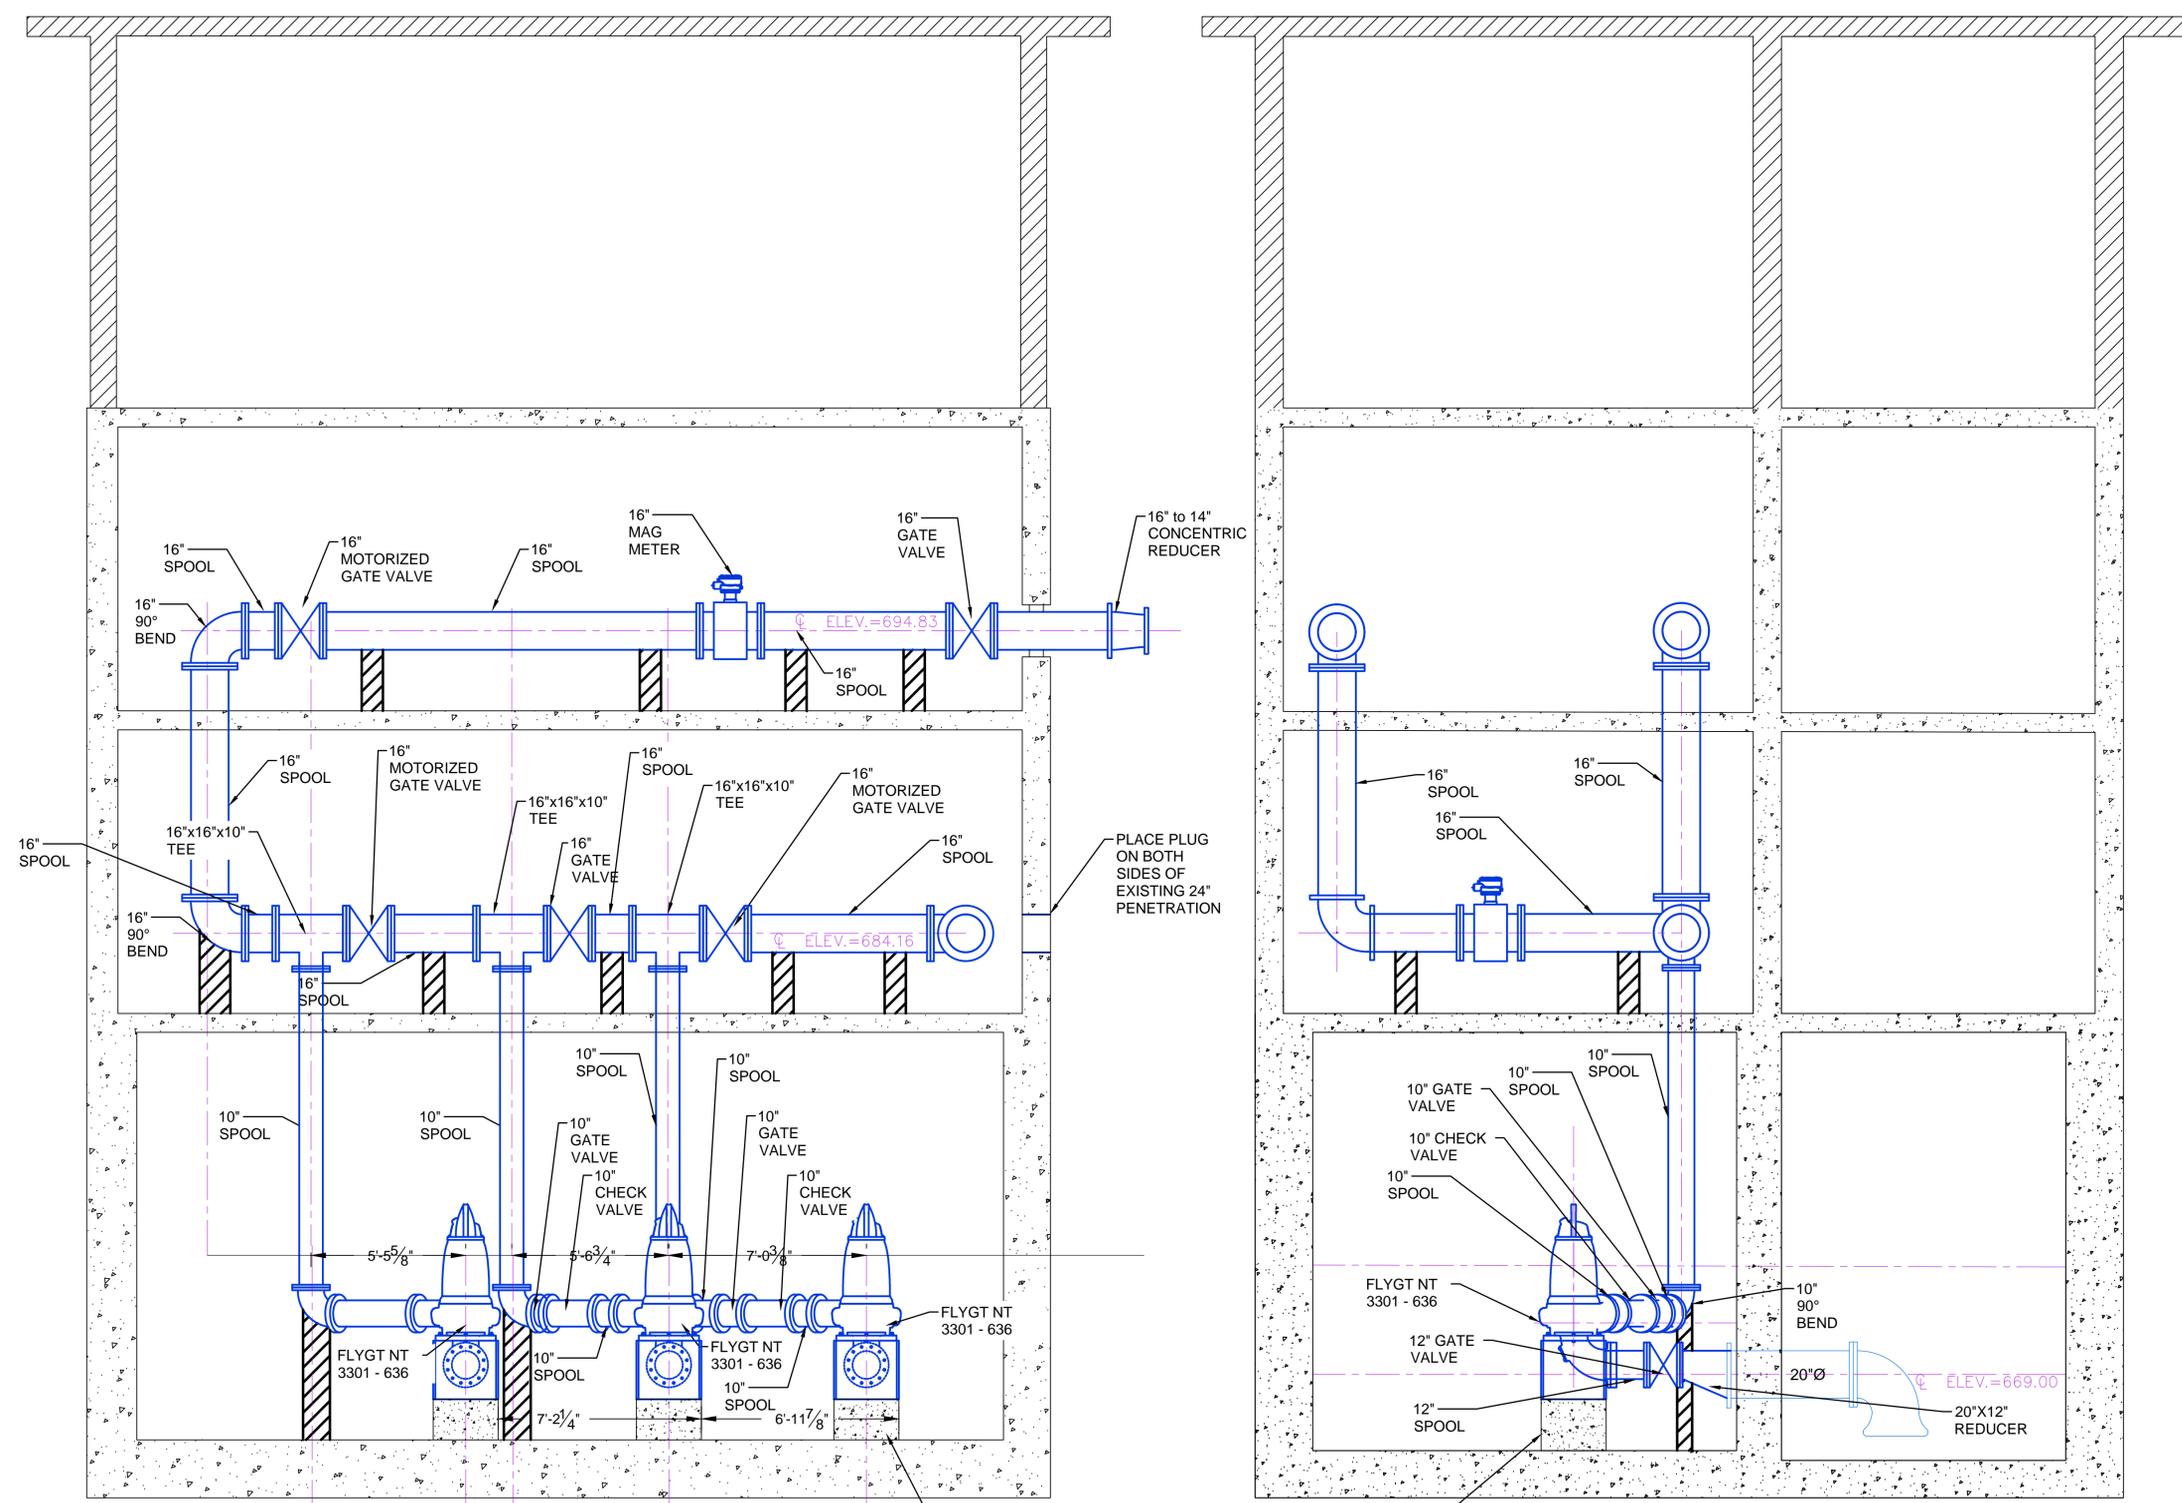

Section B-B, West Looking East

CONCRETE PUMP BASE (TYP)

CONCRETE PUMP BASE (TYP)

Section A-A, South Looking North

 
SCALE: VERT. -
 HORZ. 1" = 3'

WARNING
 UTILITY LOCATIONS ARE NOT CONFIRMED. THOSE SHOWN WERE OBTAINED FROM CITY RECORDS. THE CONTRACTOR SHALL VERIFY ALL UTILITY LOCATIONS PRIOR TO BEGINNING WORK. THE CONTRACTOR SHALL BE RESPONSIBLE FOR PROTECTING ALL UTILITIES AND SHALL BE RESPONSIBLE FOR RELOCATING OR REPAIRING ANY UTILITIES THAT INTERFERE WITH CONSTRUCTION.



City of Flint
 1101 S. Saginaw Street
 Flint, Michigan 48502

Northwest Pump Station Improvements
 Proposed Pump Station Section Views A-A and B-B



MARK	ISSUED FOR	DATE
-	EAGLE SUBMITTAL	2/14/2020
-		
-		
-		
-		
-		
-		
-		
-		

DRAWN BY: DLZ
 DESIGN BY: GJG
 CHECKED BY: GJG

DLZ JOB NUMBER: 1849-0706-00


SHEET NO. C-103

Know what's below
 Call before you dig
811 BEFORE YOU DIG CALL
 MISS DIG System, Inc.
 1-800-482-7171 www.missdig.net

DLZ
 ARCHITECTURE • ENGINEERING • PLANNING
 SURVEYING • CONSTRUCTION SERVICES

INNOVATIVE IDEAS
 EXCEPTIONAL DESIGN
 UNMATCHED CLIENT SERVICE

Layout = C-104
 PLOT DATE: 2/14/2020 1:25:53 PM
 SHEET DATE: 2/14/2020 1:25:02 PM
 BRENDAN WROBEL X:\Projects\Waterford\18500\18706 City of Flint Pump Station Rehab.dwg\18706 ELEVATIONS & SECTIONS.dwg

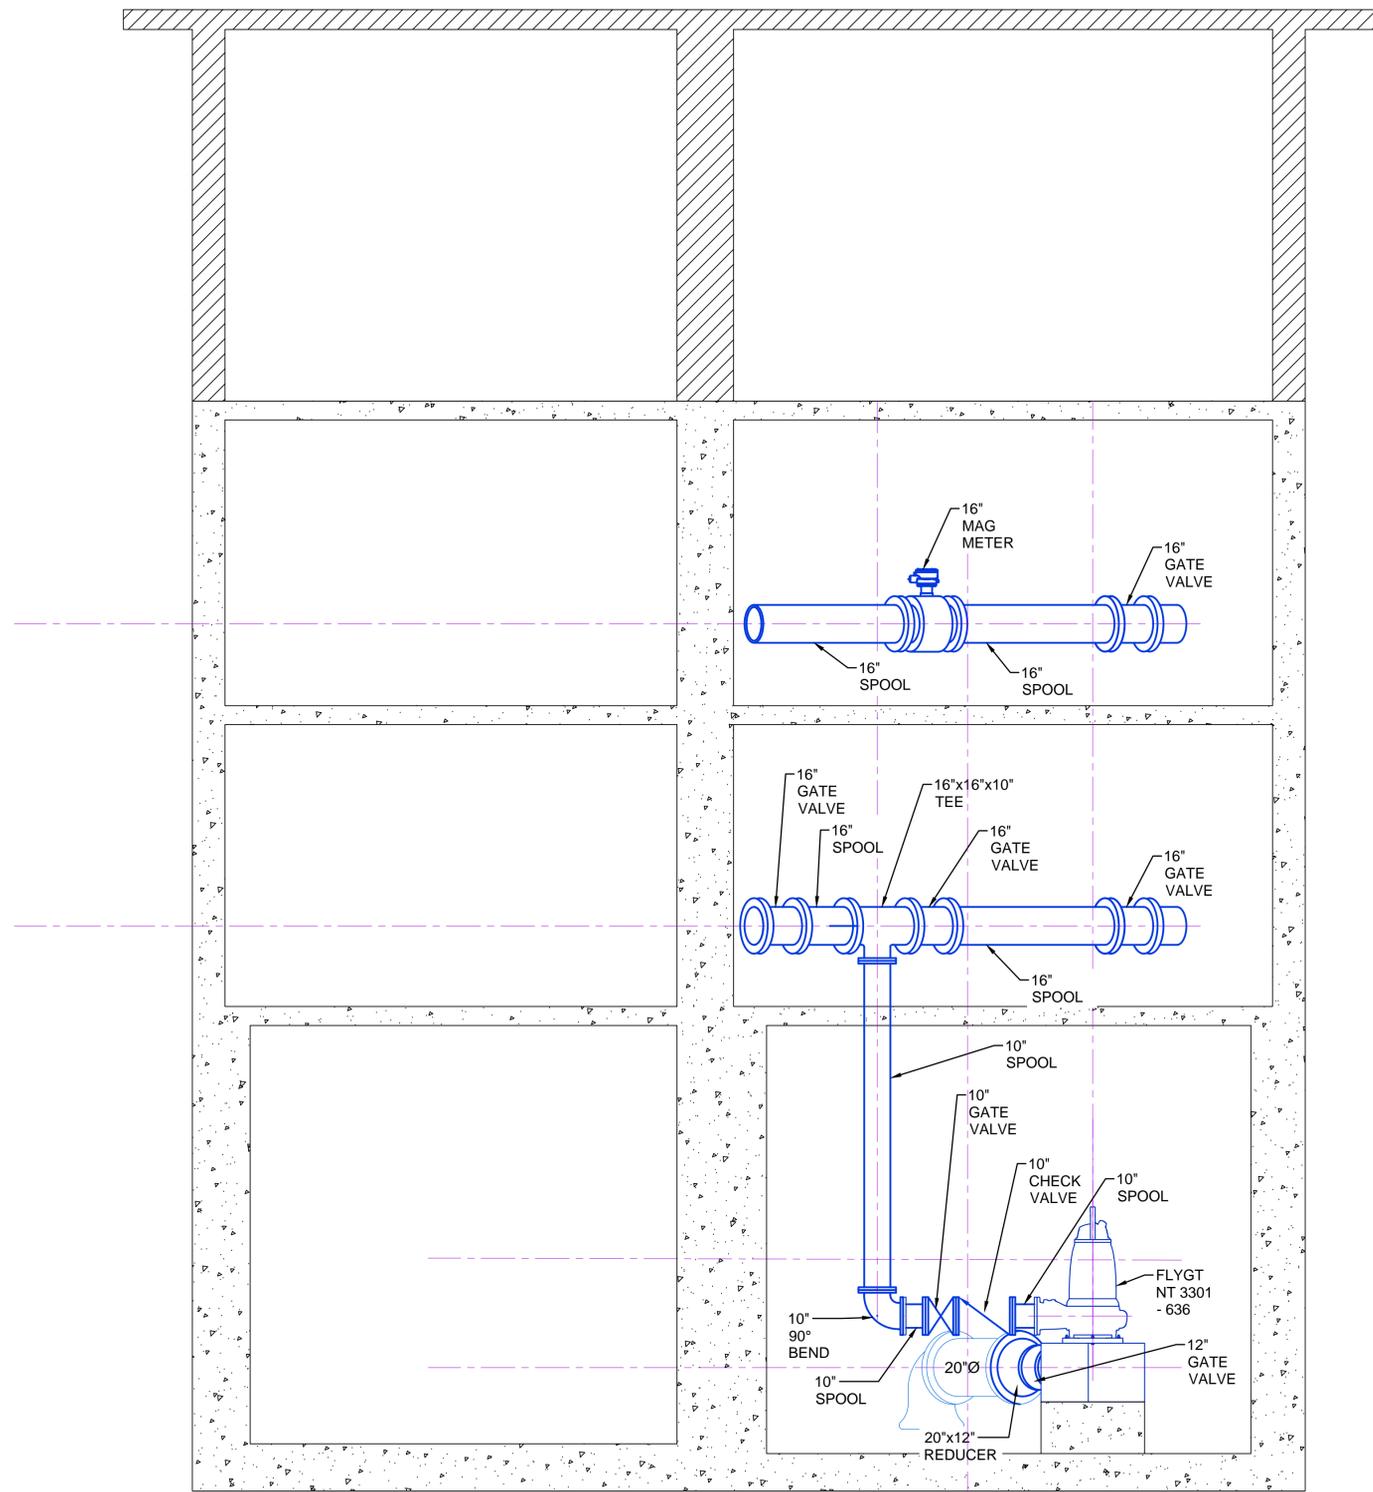

Section C-C, West Looking East

 
SCALE: VERT. -
 HORZ. 1" = 3'

WARNING
 UTILITY LOCATIONS ARE NOT CONFIRMED. THOSE SHOWN WERE OBTAINED FROM MISS DIG SYSTEM. PRIOR TO BEGINNING WORK, THE CONTRACTOR SHALL VERIFY ALL UTILITY LOCATIONS AND HE SHALL PROTECT OR HAVE RELOCATED, AS NOTED IN THE SPECIFICATIONS. ALL INTERFERENCE WITH CONSTRUCTION



City of Flint
 1101 S. Saginaw Street
 Flint, Michigan 48502

Northwest Pump Station Improvements
 Proposed Pump Station Section View C-C



MARK	ISSUED FOR	DATE
-	EAGLE SUBMITTAL	2/14/2020
-		
-		
-		
-		
-		
-		
-		
-		

DRAWN BY: DLZ
 DESIGN BY: GJG
 CHECKED BY: GJG

DLZ JOB NUMBER: 1849-0706-00


SHEET NO.
 C-104

811
 3 FULL WORKING DAYS BEFORE YOU DIG CALL
 Know what's below Call before you dig
 MISS DIG System, Inc.
 1-800-482-7171 www.missdig.net


DLZ
 ARCHITECTURE • ENGINEERING • PLANNING
 SURVEYING • CONSTRUCTION SERVICES

INNOVATIVE IDEAS
 EXCEPTIONAL DESIGN
 UNMATCHED CLIENT SERVICE

Layout = C-105
 ROOT DATE: 2/14/2020 1:52:58 PM
 SWE DATE: 2/14/2020 1:26:02 PM
 BRENDAN WROBEL X:\Projects\Waterford\18500\18706 City of Flint Pump Station Rehab.dwg\18706 ELEVATIONS & SECTIONS.dwg

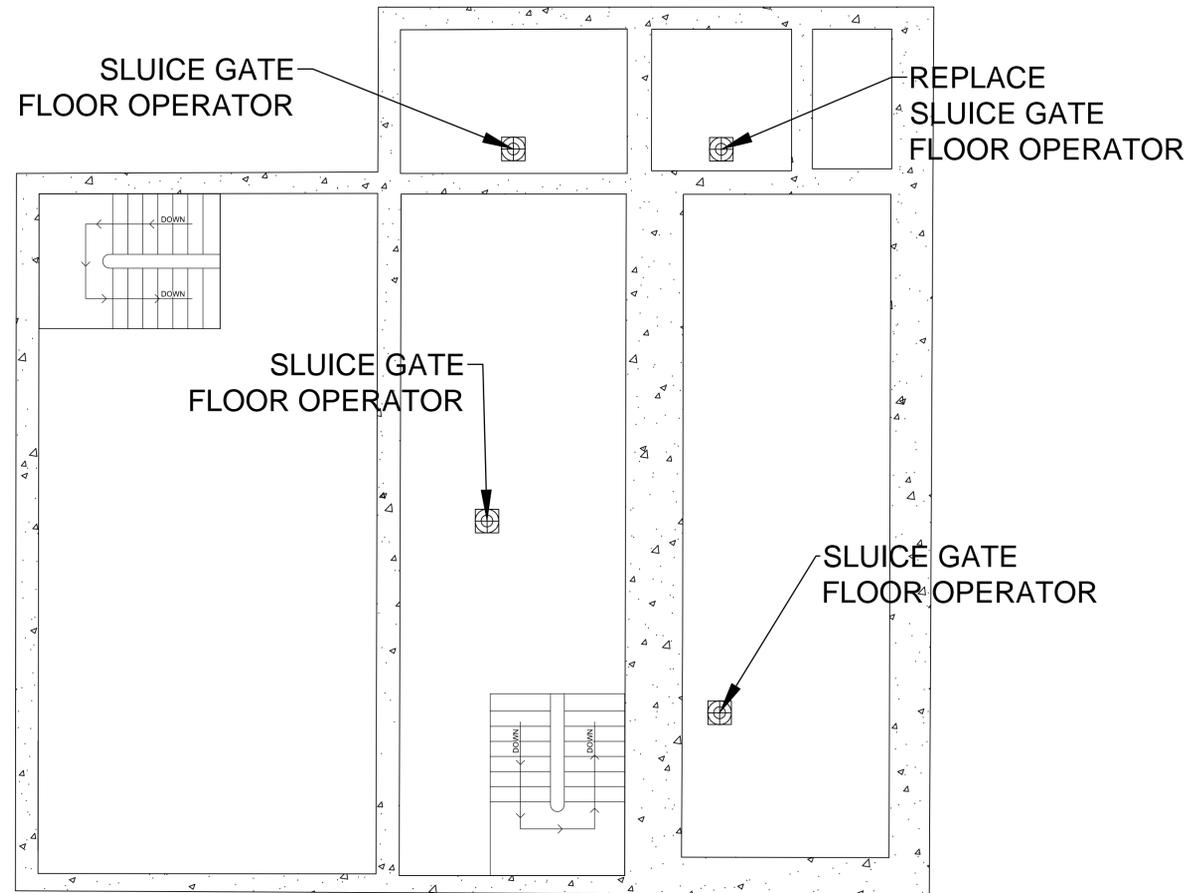


FIRST FLOOR OF BUILDING

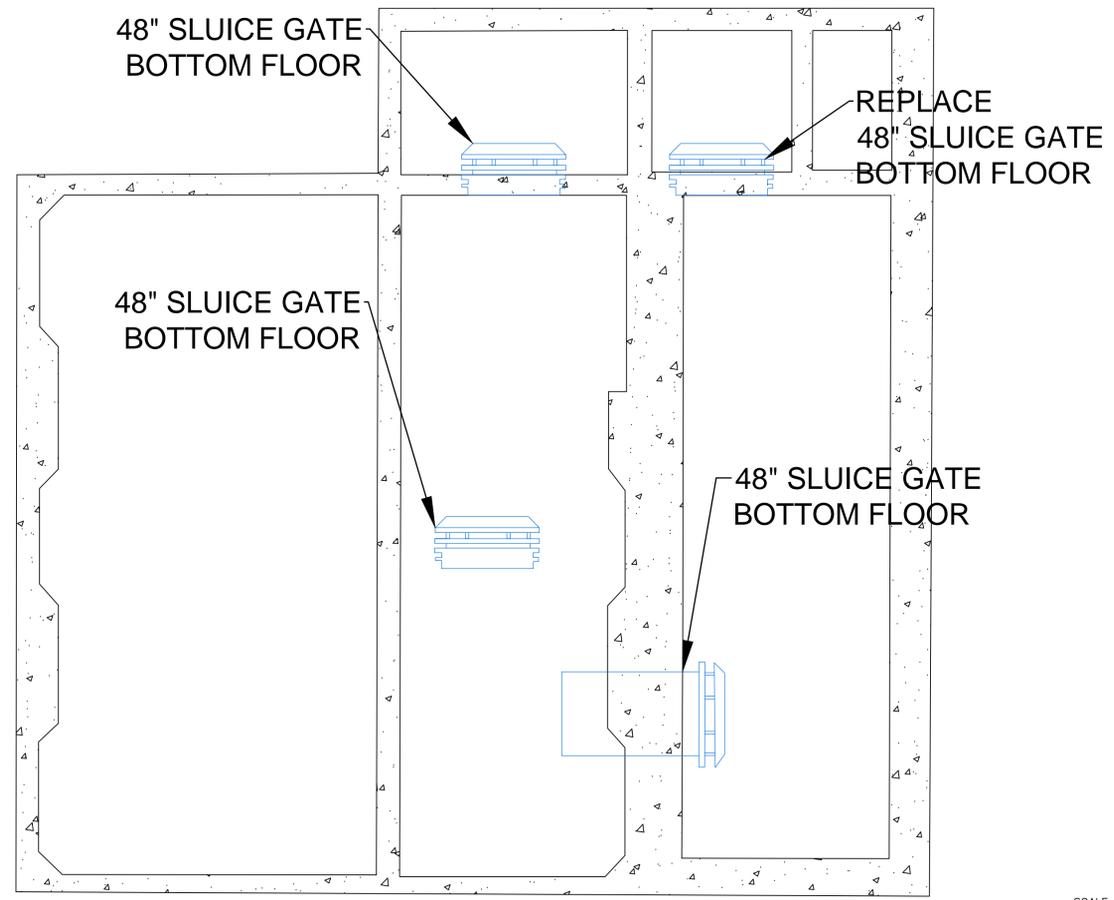

SLUICE GATE PLAN VIEW

SCALE: VERT. -
 HORZ. 1" = 4'

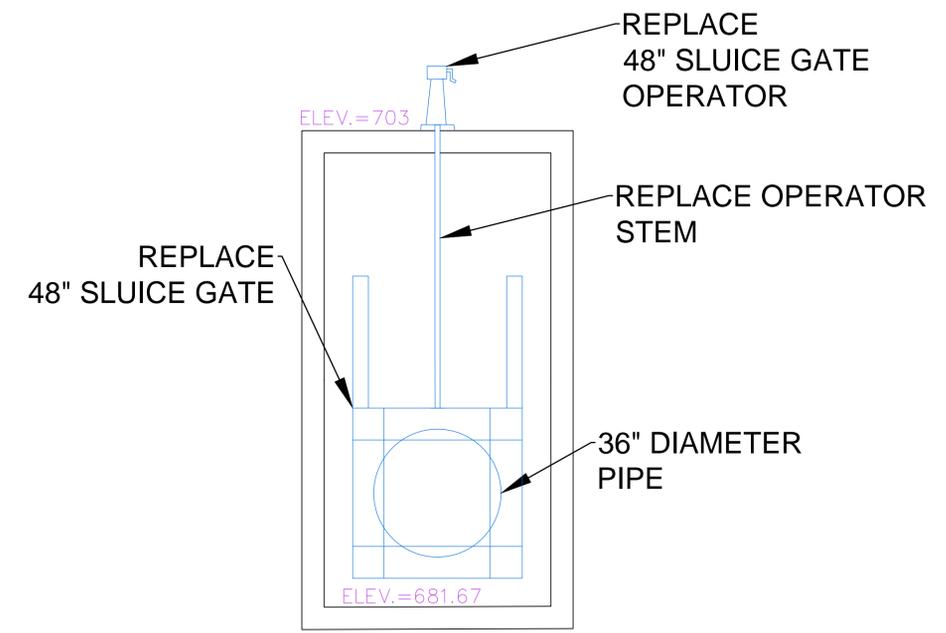

SLUICE GATE SECTION VIEW

Know what's below
 Call before you dig
 MISS DIG System, Inc.
 1-800-482-7171 www.missdig.net

811
 3 FULL WORKING DAYS
 BEFORE YOU DIG CALL

DLZ
 ARCHITECTURE • ENGINEERING • PLANNING
 SURVEYING • CONSTRUCTION SERVICES

INNOVATIVE IDEAS
 EXCEPTIONAL DESIGN
 UNMATCHED CLIENT SERVICE

WARNING
 UTILITY LOCATIONS ARE NOT
 CONFIRMED. THOSE SHOWN
 WERE OBTAINED FROM
 MISS DIG SYSTEM, INC.
 PRIOR TO BEGINNING WORK.
 THE CONTRACTOR SHALL
 VERIFY ALL UTILITIES AND
 HAVE WORK AREA STAKED
 AND HE SHALL PROTECT OR
 HAVE RELOCATED, AS NOTED
 IN THE SPECIFICATIONS. ALL
 INTERFERENCE WITH
 CONSTRUCTION



City of Flint
 1101 S. Saginaw Street
 Flint, Michigan 48502

Northwest Pump Station Improvements
 Proposed Sludge Gate Plans



MARK	ISSUED FOR	DATE
-	EAGLE SUBMITTAL	2/14/2020
-		
-		
-		
-		
-		
-		
-		
-		

DRAWN BY: DLZ
 DESIGN BY: GJG
 CHECKED BY: GJG

DLZ JOB NUMBER: 1849-0706-00


SHEET NO.
 C-105

Sheet - C-106

BRENDAN WROBEL X:\Projects\Waterford\18500\19206 City of Flint Pump Station Rehab.dwg\18706 NW Pumping Sta Improvements.dwg

SME DATE: 2/14/2020 1:46:19 PM

ROOT DATE: 2/14/2020 1:53:08 PM

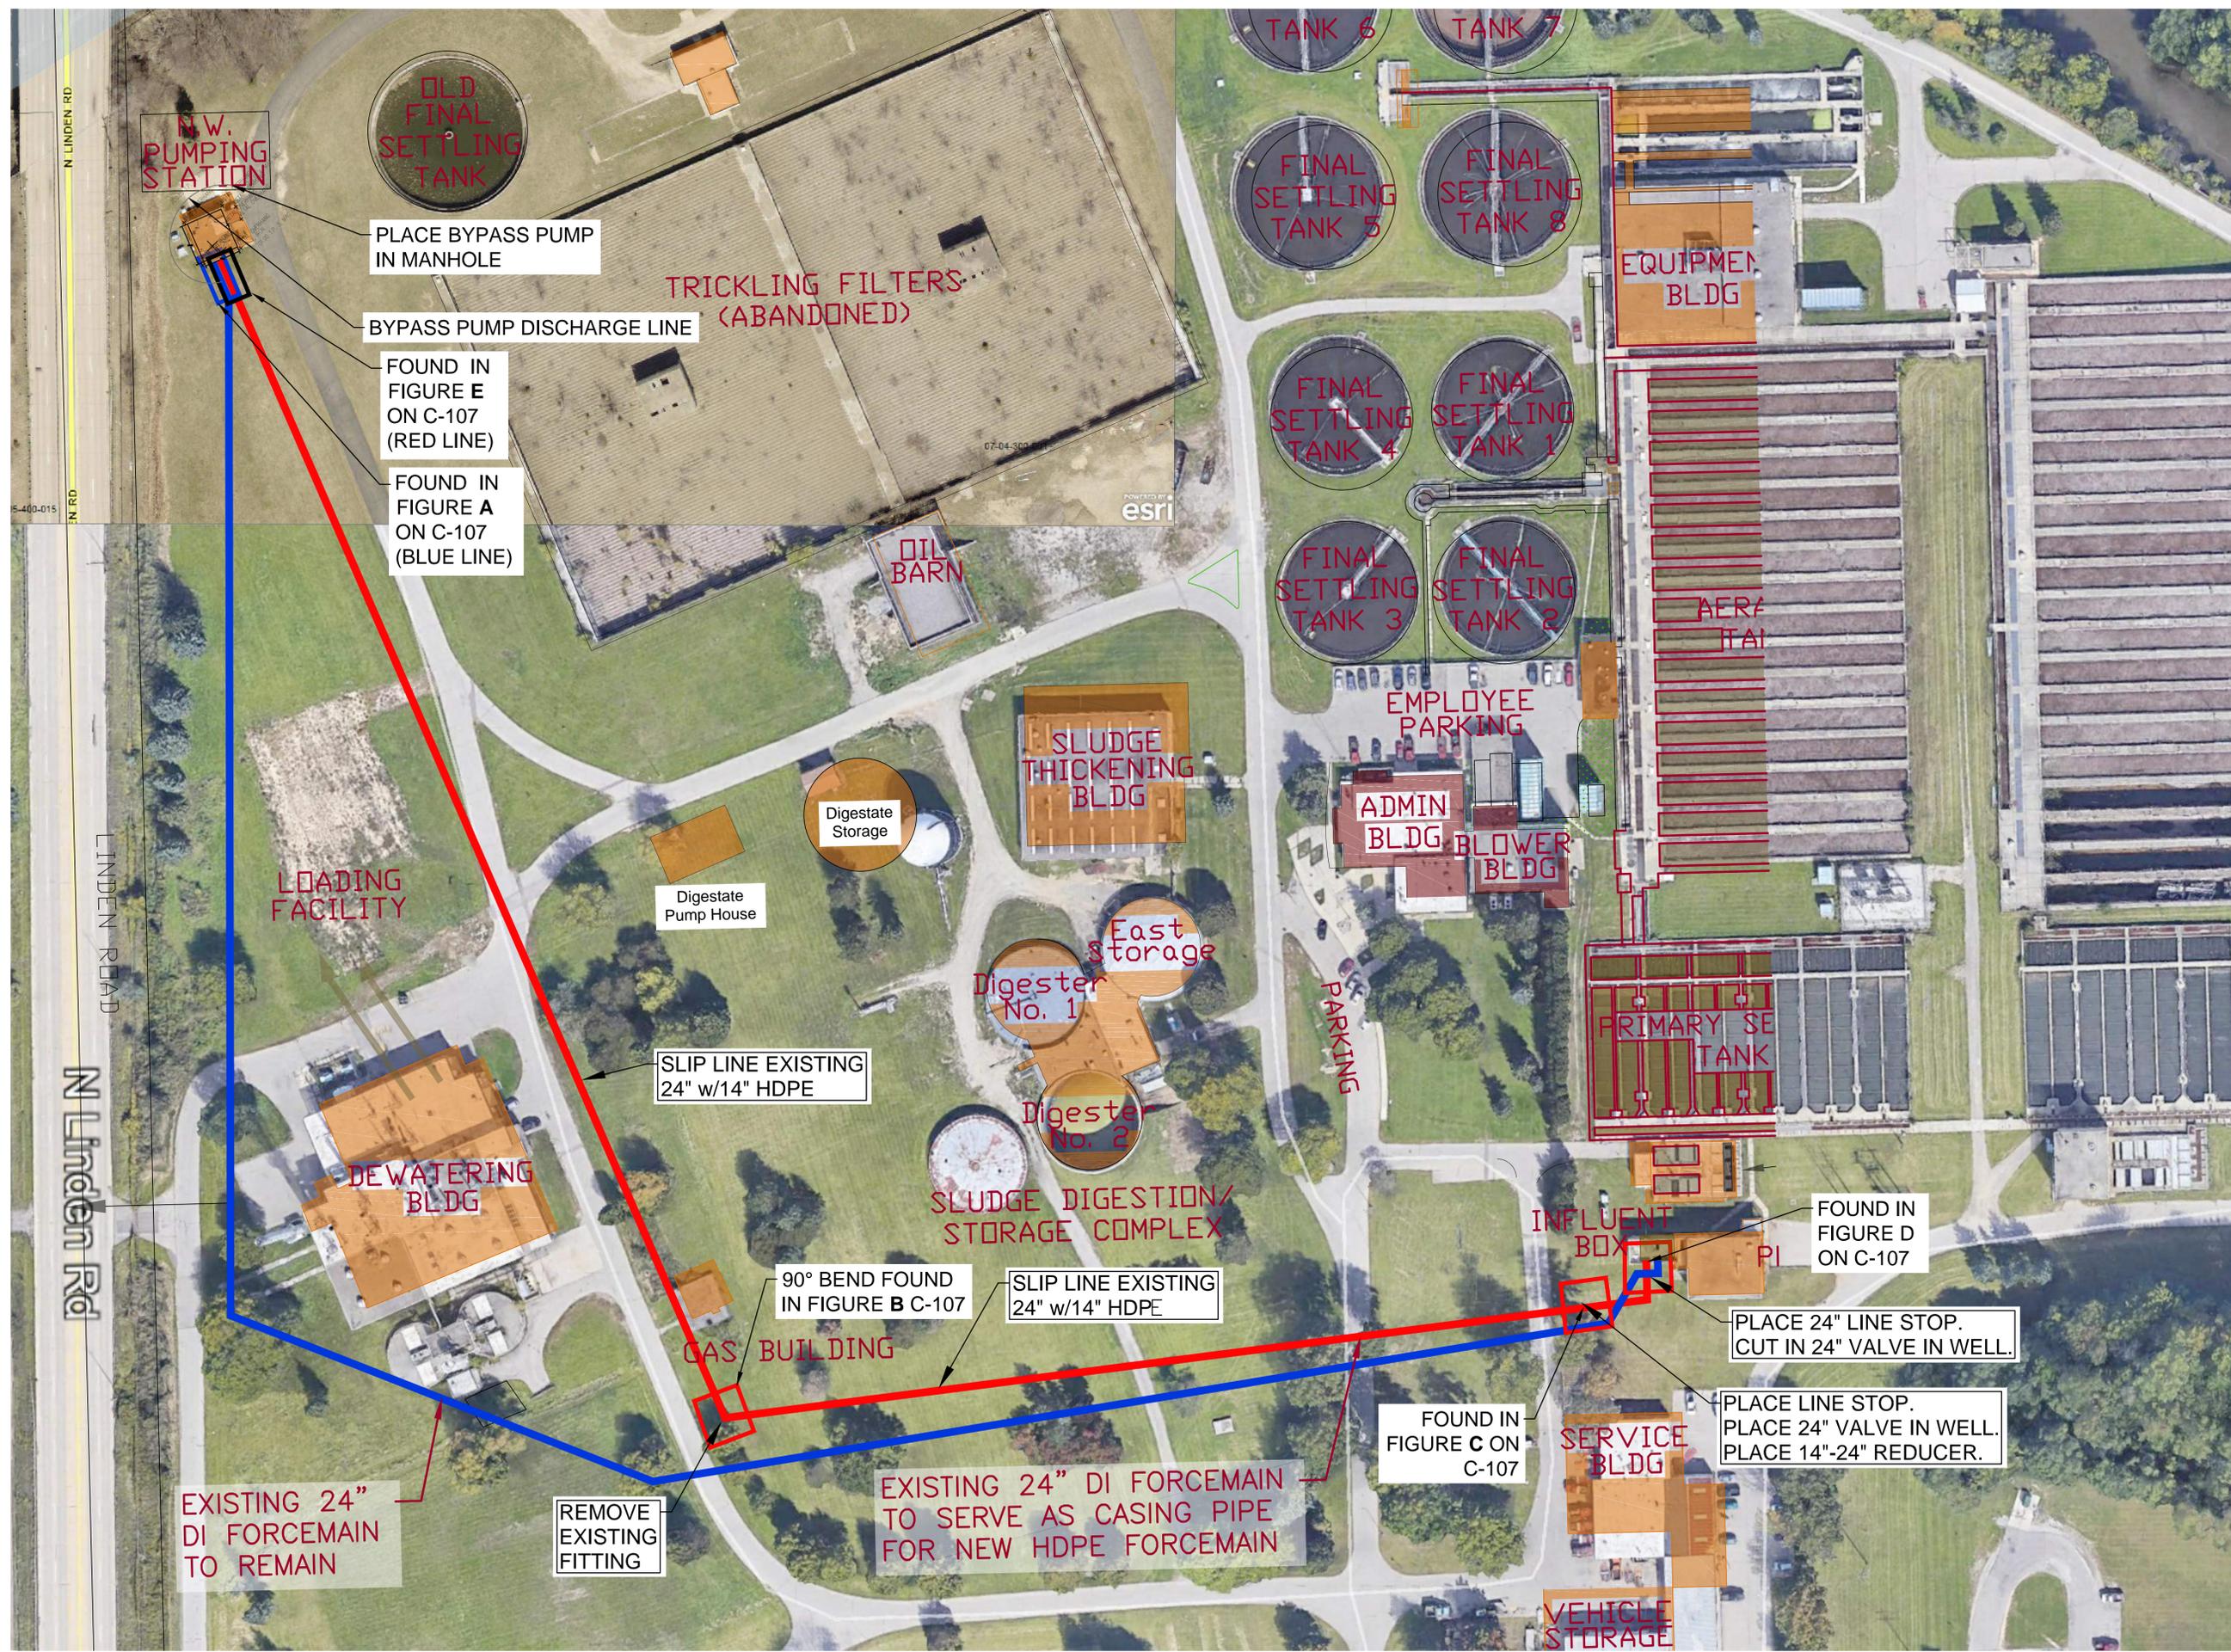

811
 3 FULL WORKING DAYS
 BEFORE YOU DIG CALL
 MISS DIG System, Inc.
 1-800-482-7171 www.missdig.net

WARNING
 UTILITY LOCATIONS ARE NOT
 CONFIRMED. THOSE SHOWN
 ARE BASED ON RECORD DRAWINGS,
 UTILITY OWNERS OR PLANS.
 THREE FULL WORKING DAYS
 BEFORE YOU DIG CALL MISS DIG.
 THE CONTRACTOR SHALL
 NOTIFY UTILITY OWNERS TO
 HAVE WORK AREA STAGED
 AND TO BE RELOCATED AS NOTED
 IN THE SPECIFICATIONS. ALL
 INTERFERENCE WITH
 CONSTRUCTION



City of Flint
 1101 S. Saginaw Street
 Flint, MI 48502

Northwest Pump Station Improvements
 Proposed Forcemain Work



NOT TO SCALE

MARK	ISSUED FOR	DATE
-	EAGLE SUBMITTAL	2/14/2020
-		
-		
-		
-		
-		
-		
-		
-		

DRAWN BY: DLZ
 DESIGN BY: GJG
 CHECKED BY: GJG

DLZ JOB NUMBER: 1849-0706-00

SHEET NO. C-106

DLZ
 ARCHITECTURE • ENGINEERING • PLANNING
 SURVEYING • CONSTRUCTION SERVICES

INNOVATIVE IDEAS
 EXCEPTIONAL DESIGN
 UNMATCHED CLIENT SERVICE

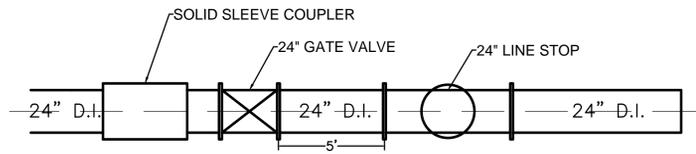


Figure A

Scale: 1"=4'

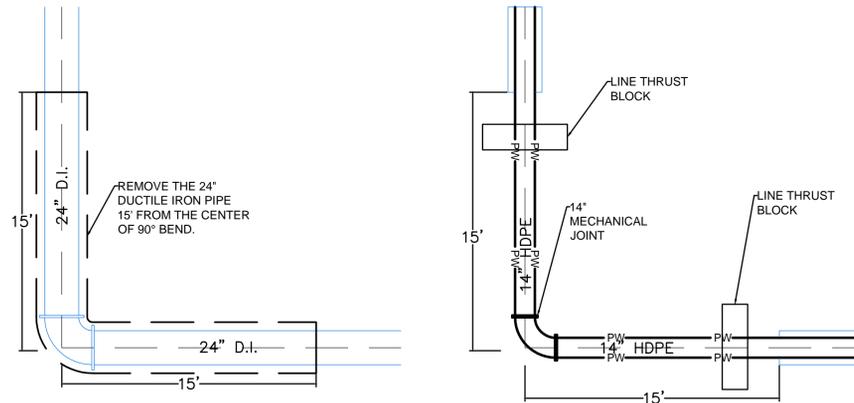


Figure B

Scale: 1"=4'

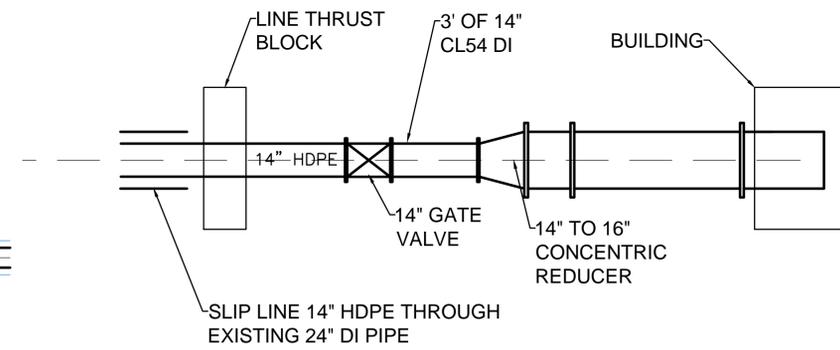


Figure C

Scale: 1"=3'

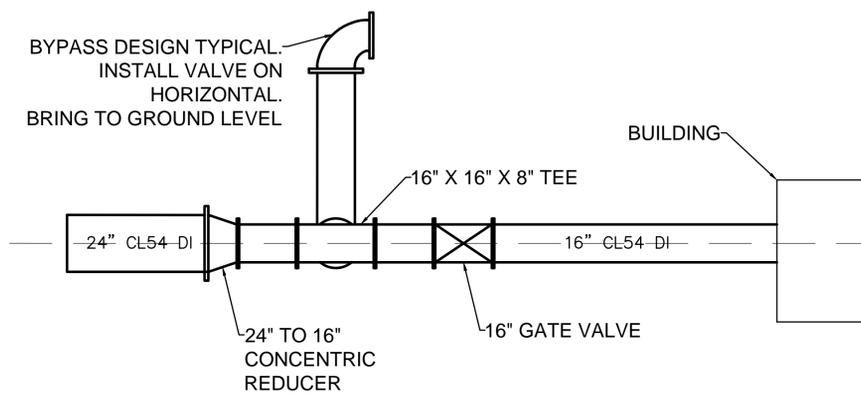


Figure D

Scale: 1"=4'

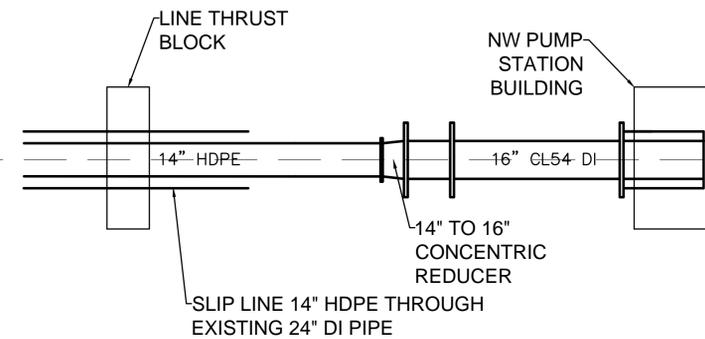


Figure E

Scale: 1"=3'

811 Know what's below
 3 FULL WORKING DAYS BEFORE YOU DIG CALL
 MISS DIG System, Inc.
 1-800-482-7171 www.missdig.net

WARNING
 UTILITY LOCATIONS ARE NOT CONFIRMED. THOSE SHOWN ON THIS PLAN ARE THE RESPONSIBILITY OF THE UTILITY OWNERS OR PLANS. THREE FULL WORKING DAYS BEFORE YOU DIG CALL MISS DIG SYSTEM, INC. TO VERIFY THE LOCATION OF ALL UTILITIES. THE CONTRACTOR SHALL NOTIFY UTILITY OWNERS TO HAVE WORK AREA STAGED AND TO BE RELOCATED AS NOTED IN THE SPECIFICATIONS. ALL INTERFERENCE WITH CONSTRUCTION



City of Flint
 1101 S. Saginaw Street
 Flint, MI 48502

DLZ
 ARCHITECTURE + ENGINEERING + PLANNING + CONSTRUCTION SERVICES
 INNOVATIVE IDEAS
 EXCEPTIONAL DESIGN
 UNMATCHED CLIENT SERVICE

Northwest Pump Station Improvements
 Proposed Forcemain Work


NOT TO SCALE

MARK	ISSUED FOR	DATE
-	EAGLE SUBMITTAL	2/14/2020
-		
-		
-		
-		
-		
-		
-		

DRAWN BY: DLZ
 DESIGN BY: GJG
 CHECKED BY: GJG

DLZ JOB NUMBER: 1849-0706-00

SHEET NO.
C-107

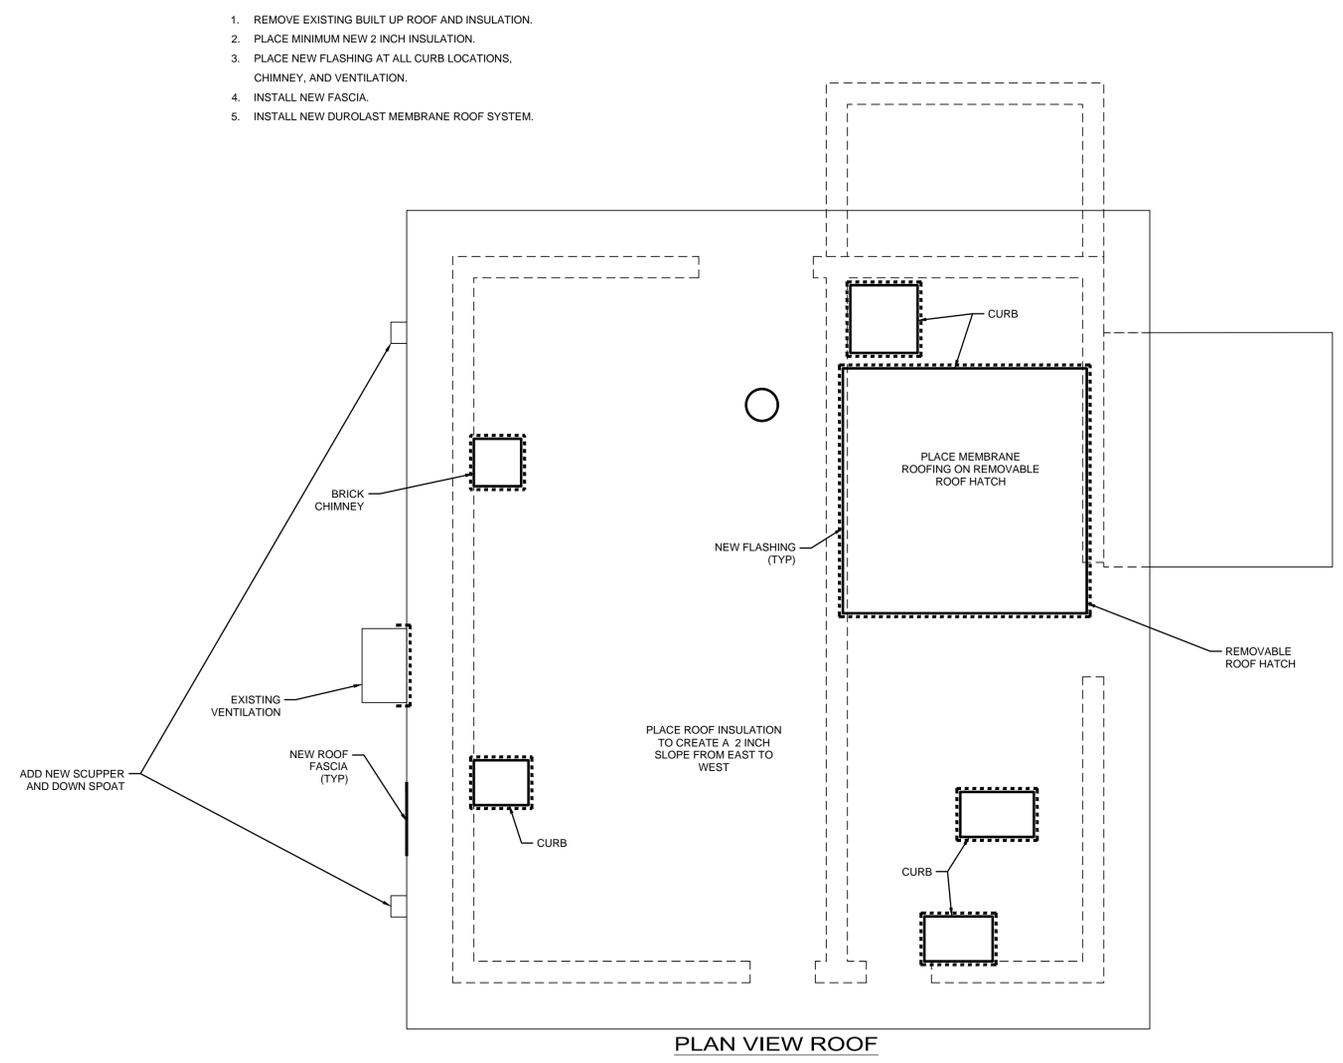

1. REMOVE EXISTING BUILT UP ROOF AND INSULATION.
2. PLACE MINIMUM NEW 2 INCH INSULATION.
3. PLACE NEW FLASHING AT ALL CURB LOCATIONS, CHIMNEY, AND VENTILATION.
4. INSTALL NEW FASCIA.
5. INSTALL NEW DURALAST MEMBRANE ROOF SYSTEM.


SCALE: VERT. -
 HORZ. 1" = 4'

WARNING
 UTILITY LOCATIONS ARE NOT CONFIRMED. THOSE SHOWN WERE OBTAINED FROM CONSTRUCTION RECORDS. THREE FULL WORKING DAYS PRIOR TO BEGINNING WORK, THE CONTRACTOR SHALL VERIFY THE LOCATION AND DEPTH OF ALL UTILITIES AND HAVE WORK AREA STAKED AND HE SHALL PROTECT OR HAVE RELOCATED, AS NOTED IN THE SPECIFICATIONS. ALL INTERFERE WITH CONSTRUCTION.



City of Flint
 1101 S. Saginaw Street
 Flint, Michigan 48502

Northwest Pump Station Improvements
 Proposed Roof Plan

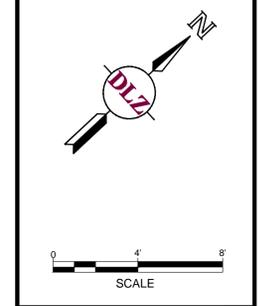

MARK	ISSUED FOR	DATE
-	EAGLE SUBMITTAL	2/14/2020
-		
-		
-		
-		
-		
-		
-		
-		

DRAWN BY: DLZ
 DESIGN BY: GJG
 CHECKED BY: GJG

DLZ JOB NUMBER: 1849-0706-00


SHEET NO.
 C-108

811 BEFORE YOU DIG CALL
 Know what's below
 Call before you dig
 MISS DIG System, Inc.
 1-800-482-7171 www.missdig.net




Layout = E-101
 RUT DATE: 2/14/2020 1:53:37 PM
 SWE DATE: 2/14/2020 1:42:46 PM
 BRENDAN WARBEL X:\Projects\Waterfor18500\18706 City of Flint Pump Station Rehabilitation\18706 Electrical.dwg

GENERAL ELECTRIC
 MOTOR CONTROL CENTER

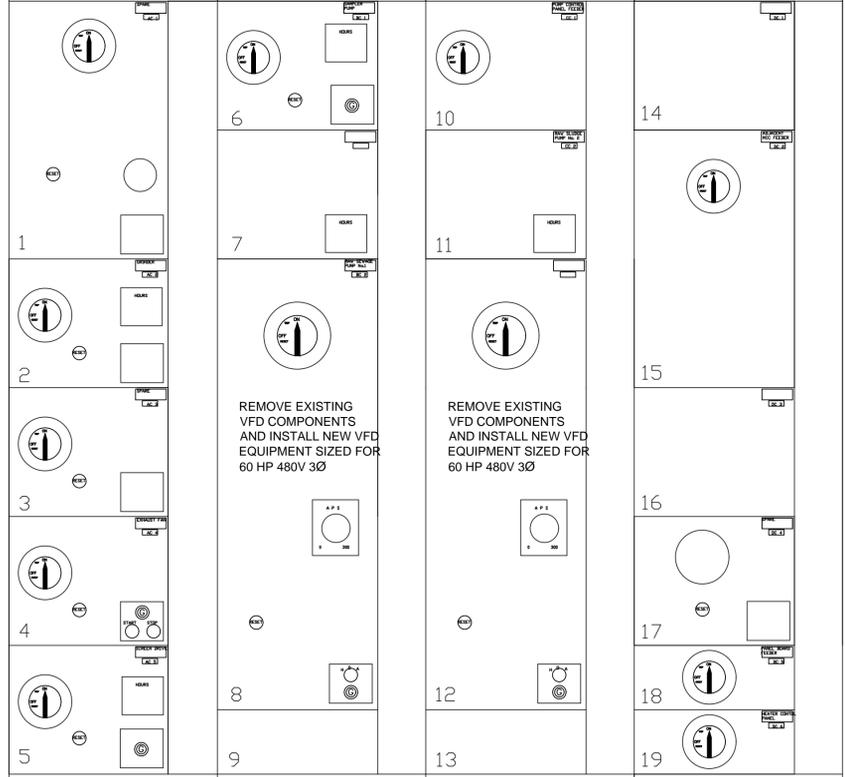


MCC P3

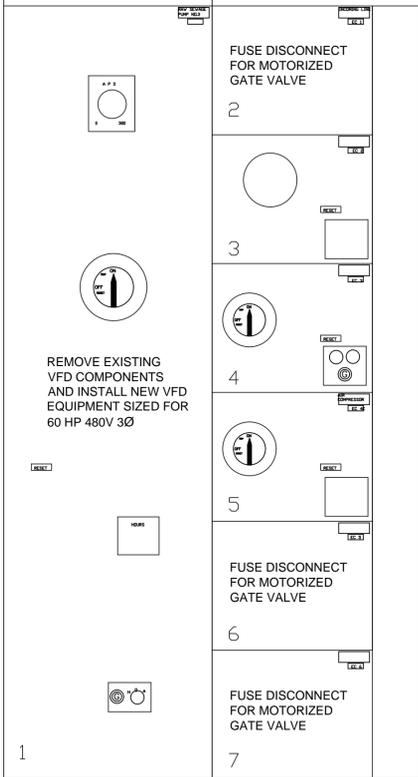

MCC PX9

SCALE: VERT. -
 HORZ.

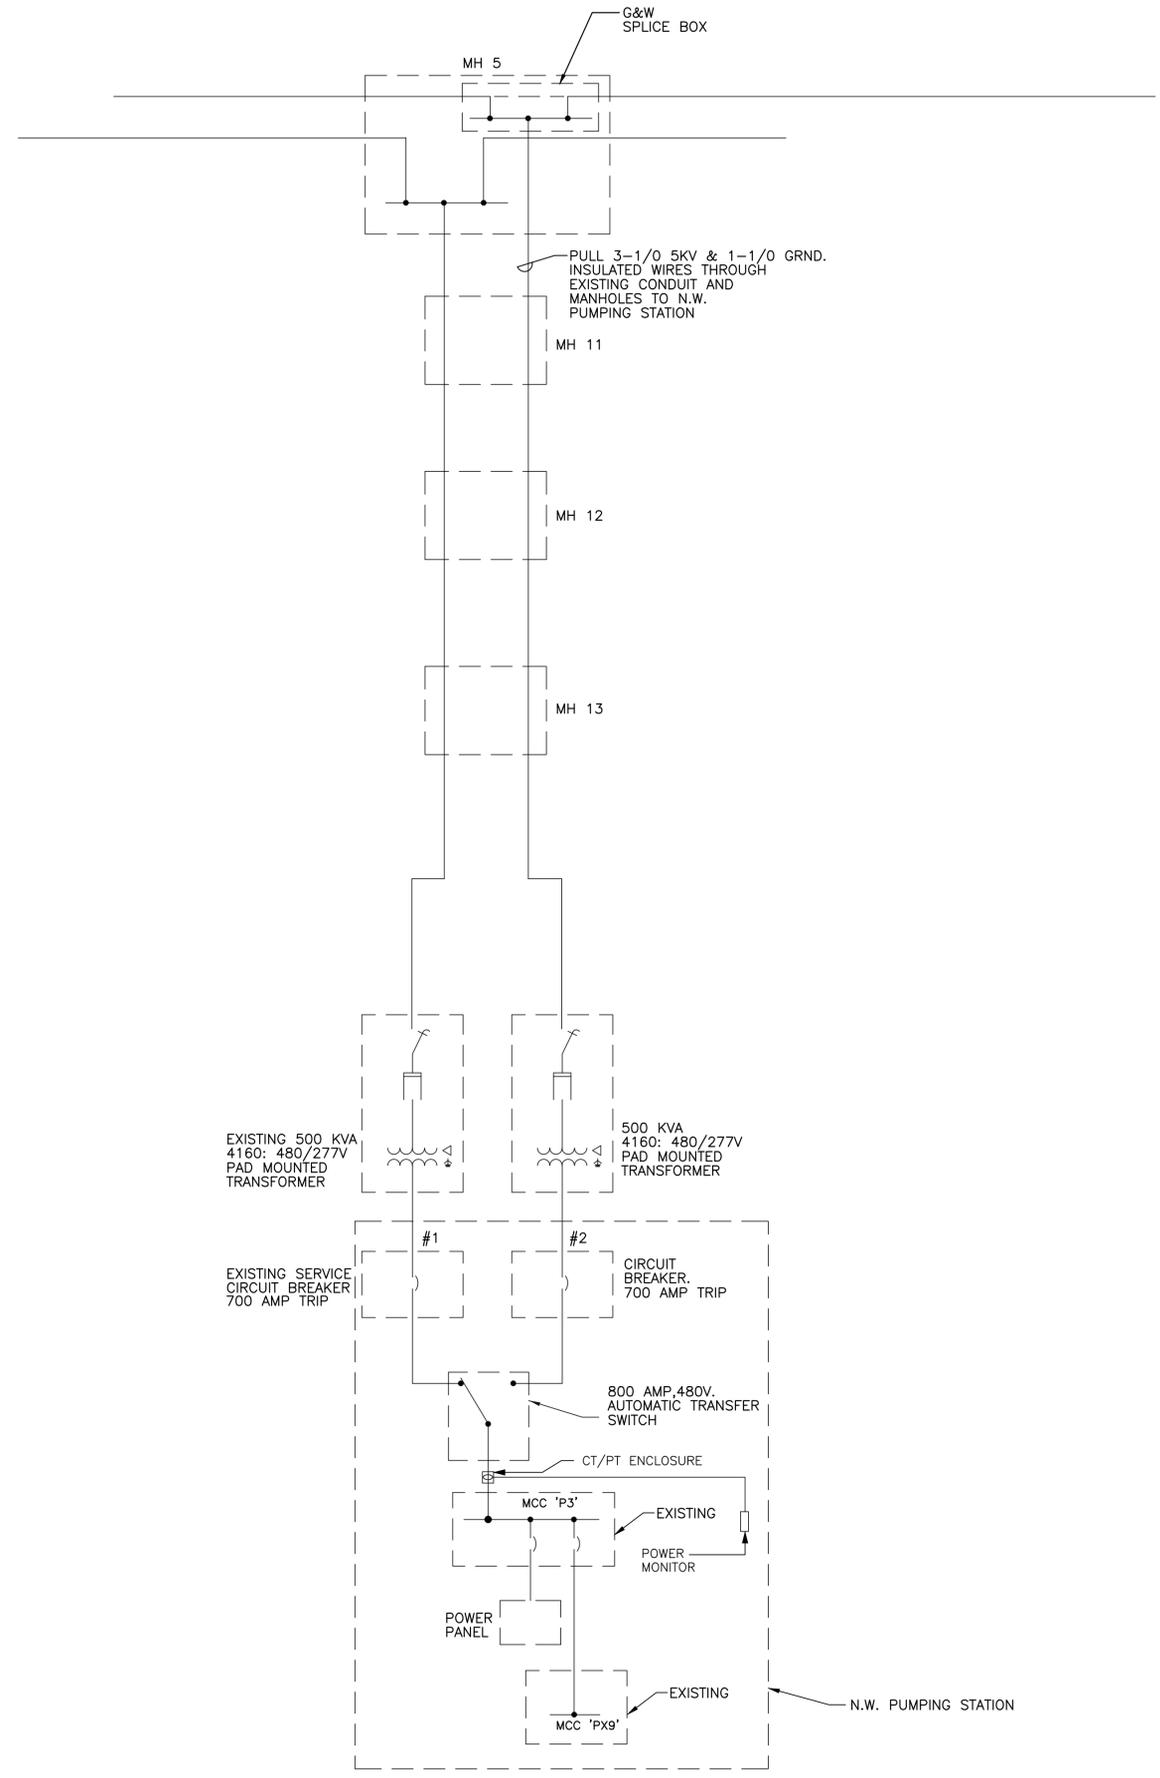

EXISTING ELECTRICAL DISTRIBUTION SYSTEM

Know what's below
 Call before you dig
 MISS DIG System, Inc.
 1-800-482-7171 www.missdig.net

811
 3 FULL WORKING DAYS
 BEFORE YOU DIG CALL

DLZ
 ARCHITECTURE • ENGINEERING • PLANNING
 SURVEYING • CONSTRUCTION SERVICES

INNOVATIVE IDEAS
 EXCEPTIONAL DESIGN
 UNMATCHED CLIENT SERVICE

WARNING
 UTILITY LOCATIONS ARE NOT CONFIRMED. THOSE SHOWN WERE OBTAINED FROM MISS DIG SYSTEM, INC. THREE FULL WORKING DAYS PRIOR TO BEGINNING WORK. THE CONTRACTOR SHALL VERIFY ALL UTILITY LOCATIONS AND HAVE WORK AREA STAKED AND HE SHALL PROTECT OR HAVE RELOCATED, AS NOTED IN THE SPECIFICATIONS. ALL INTERFERENCE WITH CONSTRUCTION



City of Flint
 1101 S. Saginaw Street
 Flint, Michigan 48502

Northwest Pump Station Improvements
 Electrical Design

NOT TO SCALE


MARK	ISSUED FOR	DATE
-	EAGLE SUBMITTAL	2/14/2020
-	-	-
-	-	-
DRAWN BY: DLZ
 DESIGN BY: GJG
 CHECKED BY: GJG

DLZ JOB NUMBER: 1849-0706-00

SHEET NO.
E-101

Layout = E-102
 RUT DATE: 2/14/2020 1:53:38 PM
 BRENDAN WARBEL X:\Projects\WaterForA18500\18706 City of Flint Pump Station Rehabilitation\18706 Electrical.dwg

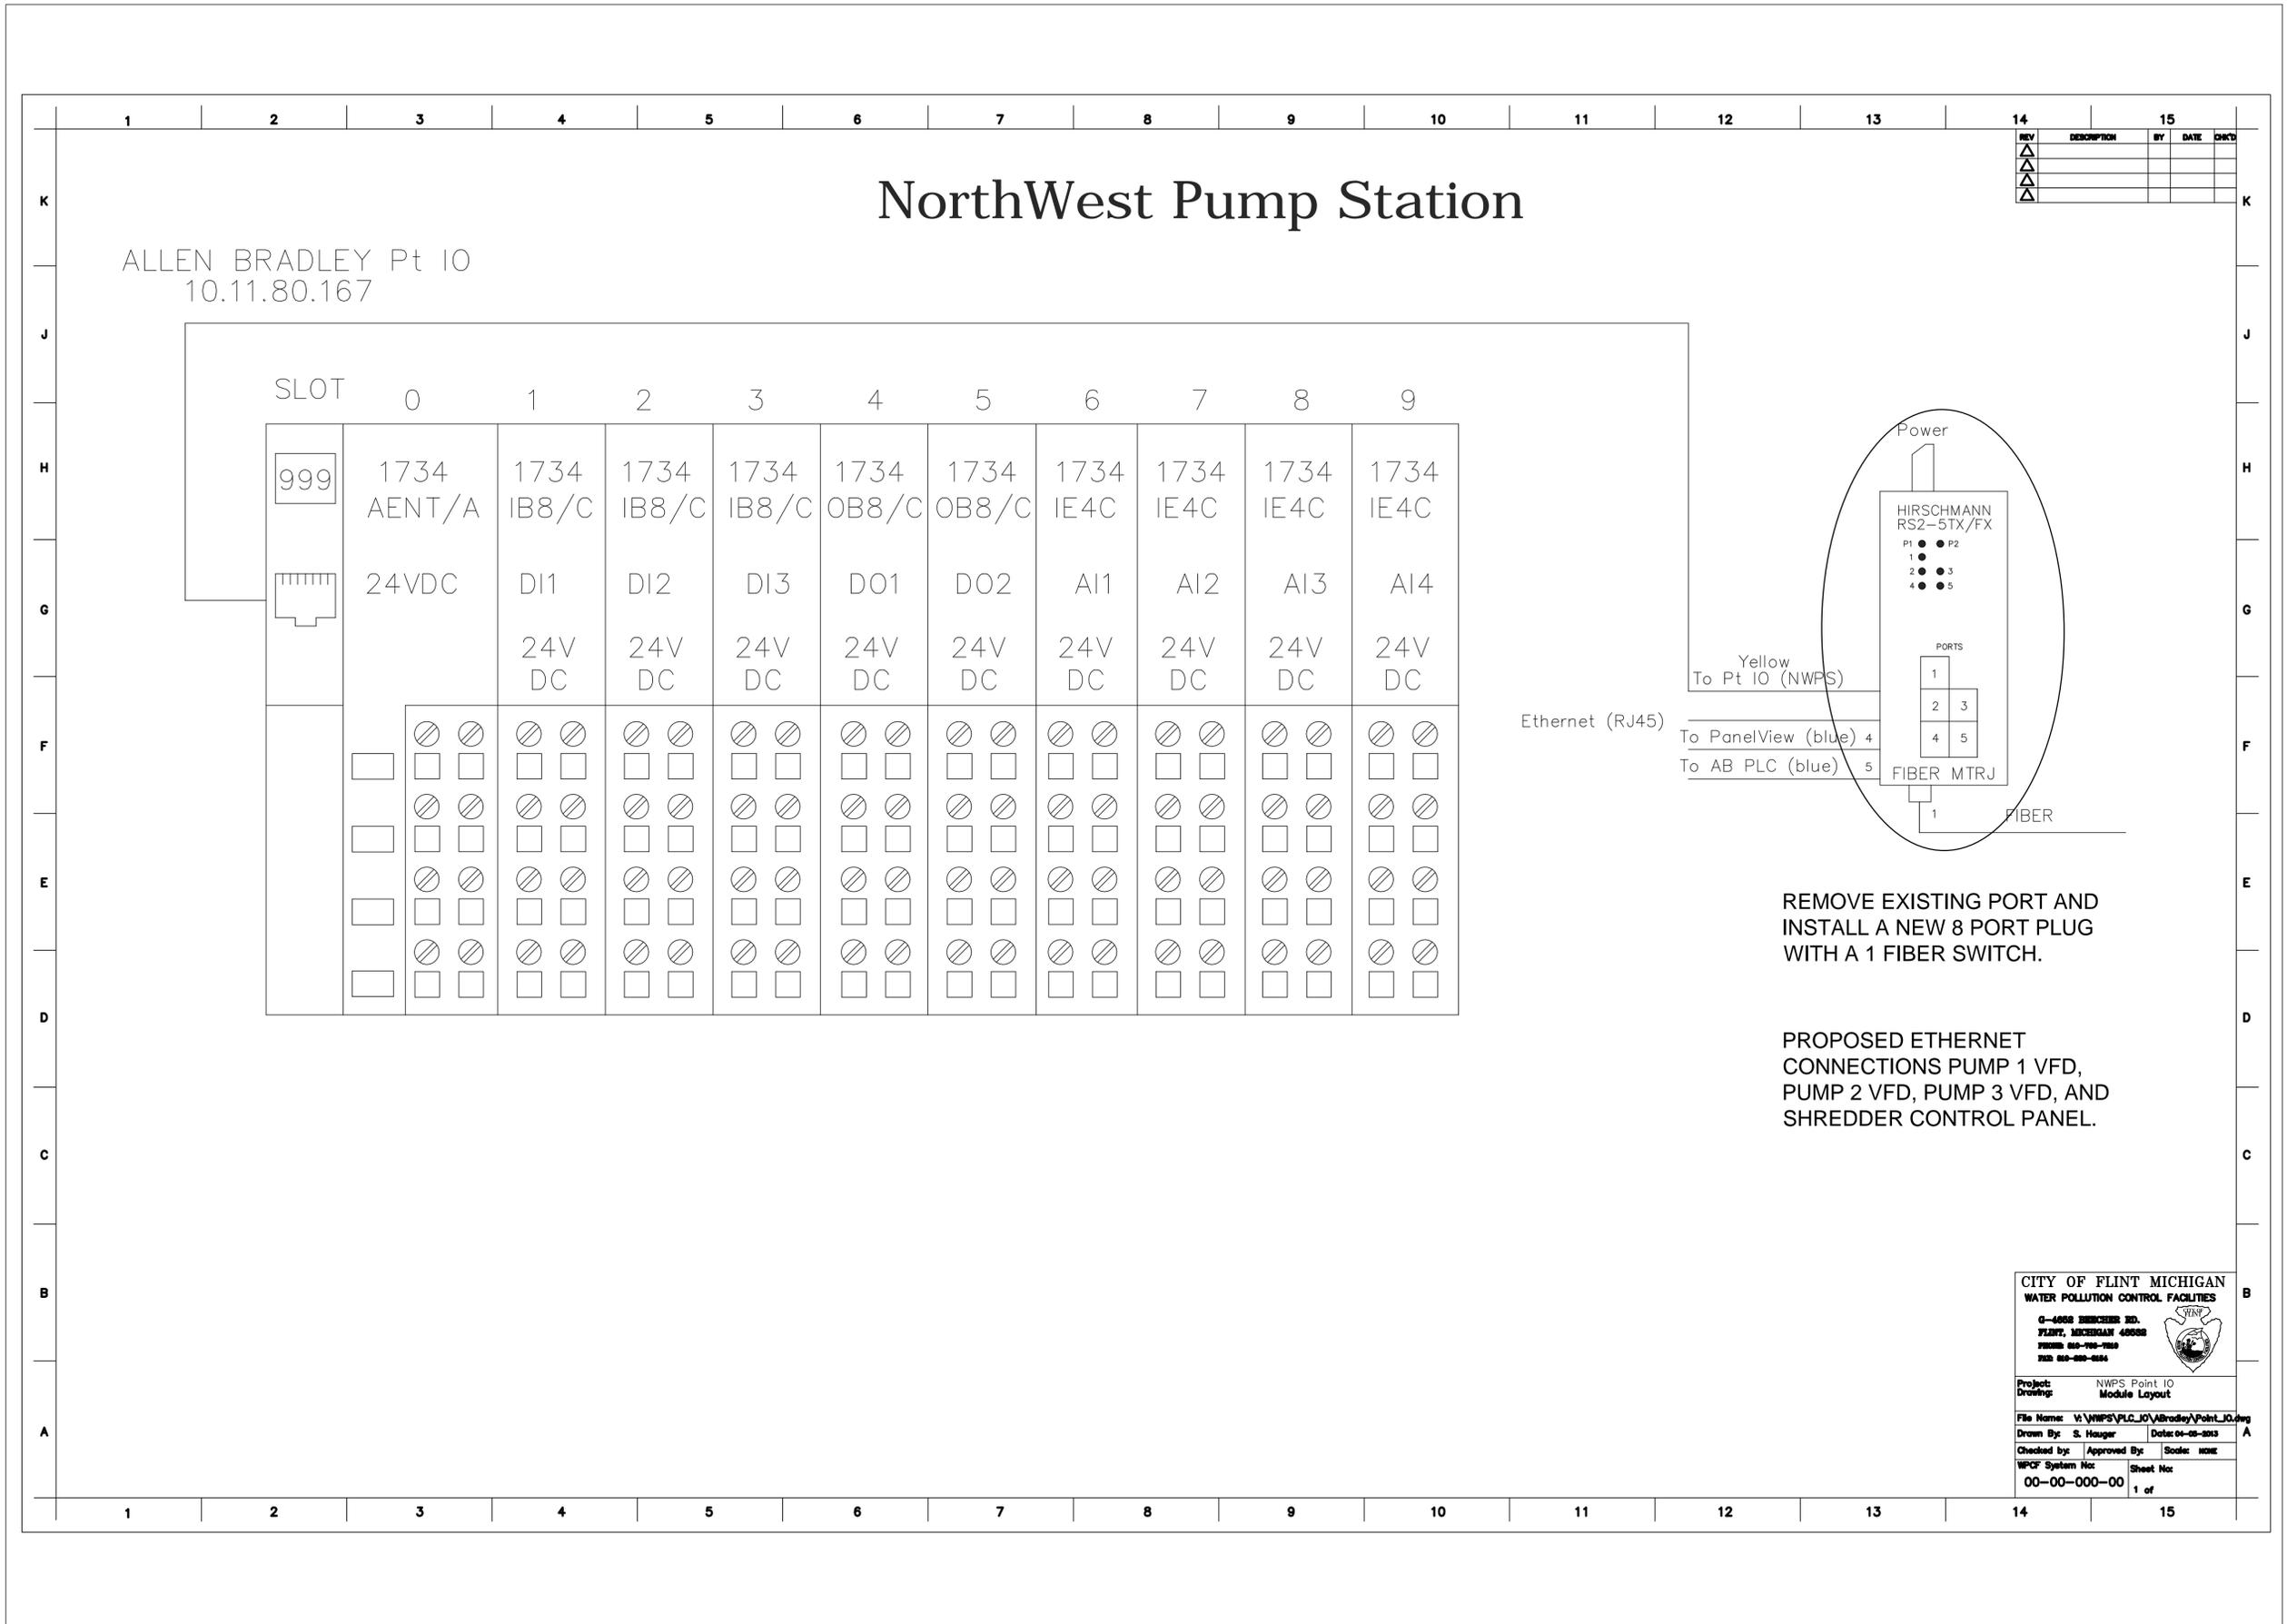

REV	DESCRIPTION	BY	DATE	CHKD

CITY OF FLINT MICHIGAN
WATER POLLUTION CONTROL FACILITIES

0-4000 SHERWOOD RD.
 FLINT, MICHIGAN 48908
 PHONE: 810-750-7500
 FAX: 810-820-0104

Project: NWPS Point IO
 Drawing: Module Layout

File Name: Y:\NWPS\PLC_IO\ABradley\Point_IO.dwg
 Drawn By: S. Hauger Date: 06-09-2013
 Checked by: Approved By: Scale: NMT
 WPCF System No: 00-00-000-00 Sheet No: 1 of

811
3 FULL WORKING DAYS
BEFORE YOU DIG CALL
Know what's below
Call before you dig
MISS DIG System, Inc.
1-800-482-7171 www.missdig.net

INNOVATIVE IDEAS
EXCEPTIONAL DESIGN
UNMATCHED CLIENT SERVICE

UTILITY LOCATIONS ARE NOT
CONFIRMED. THOSE SHOWN
WERE OBTAINED FROM
EXISTING RECORDS. ALL
THREE FULL WORKING DAYS
PRIOR TO BEGINNING WORK.
THE CONTRACTOR SHALL
VERIFY ALL UTILITY LOCATIONS
AND HE SHALL PROTECT OR
HAVE RELOCATED, AS NOTED
IN THE SPECIFICATIONS. ALL
INTERFERE WITH
CONSTRUCTION

ARCHITECTURE • ENGINEERING • PLANNING
SURVEYING • CONSTRUCTION SERVICES

City of Flint
 1101 S. Saginaw Street
 Flint, Michigan 48502

Northwest Pump Station Improvements
 Electrical Design

NOT TO SCALE

MARK	ISSUED FOR	DATE
	EAGLE SUBMITTAL	2/14/2020


DRAWN BY: DLZ
 DESIGN BY: GJG
 CHECKED BY: GJG

DLZ JOB NUMBER: 1849-0706-00

SHEET NO. E-102

SCALE: VERT. -
HORIZ.

Layout = E-103
 RUT DATE: 2/14/2020 1:53:43 PM
 BRENDAN WARBEL X:\Projects\WaterforA18500\18706 City of Flint Pump Station Rehabilitation\18706 Electrical.dwg

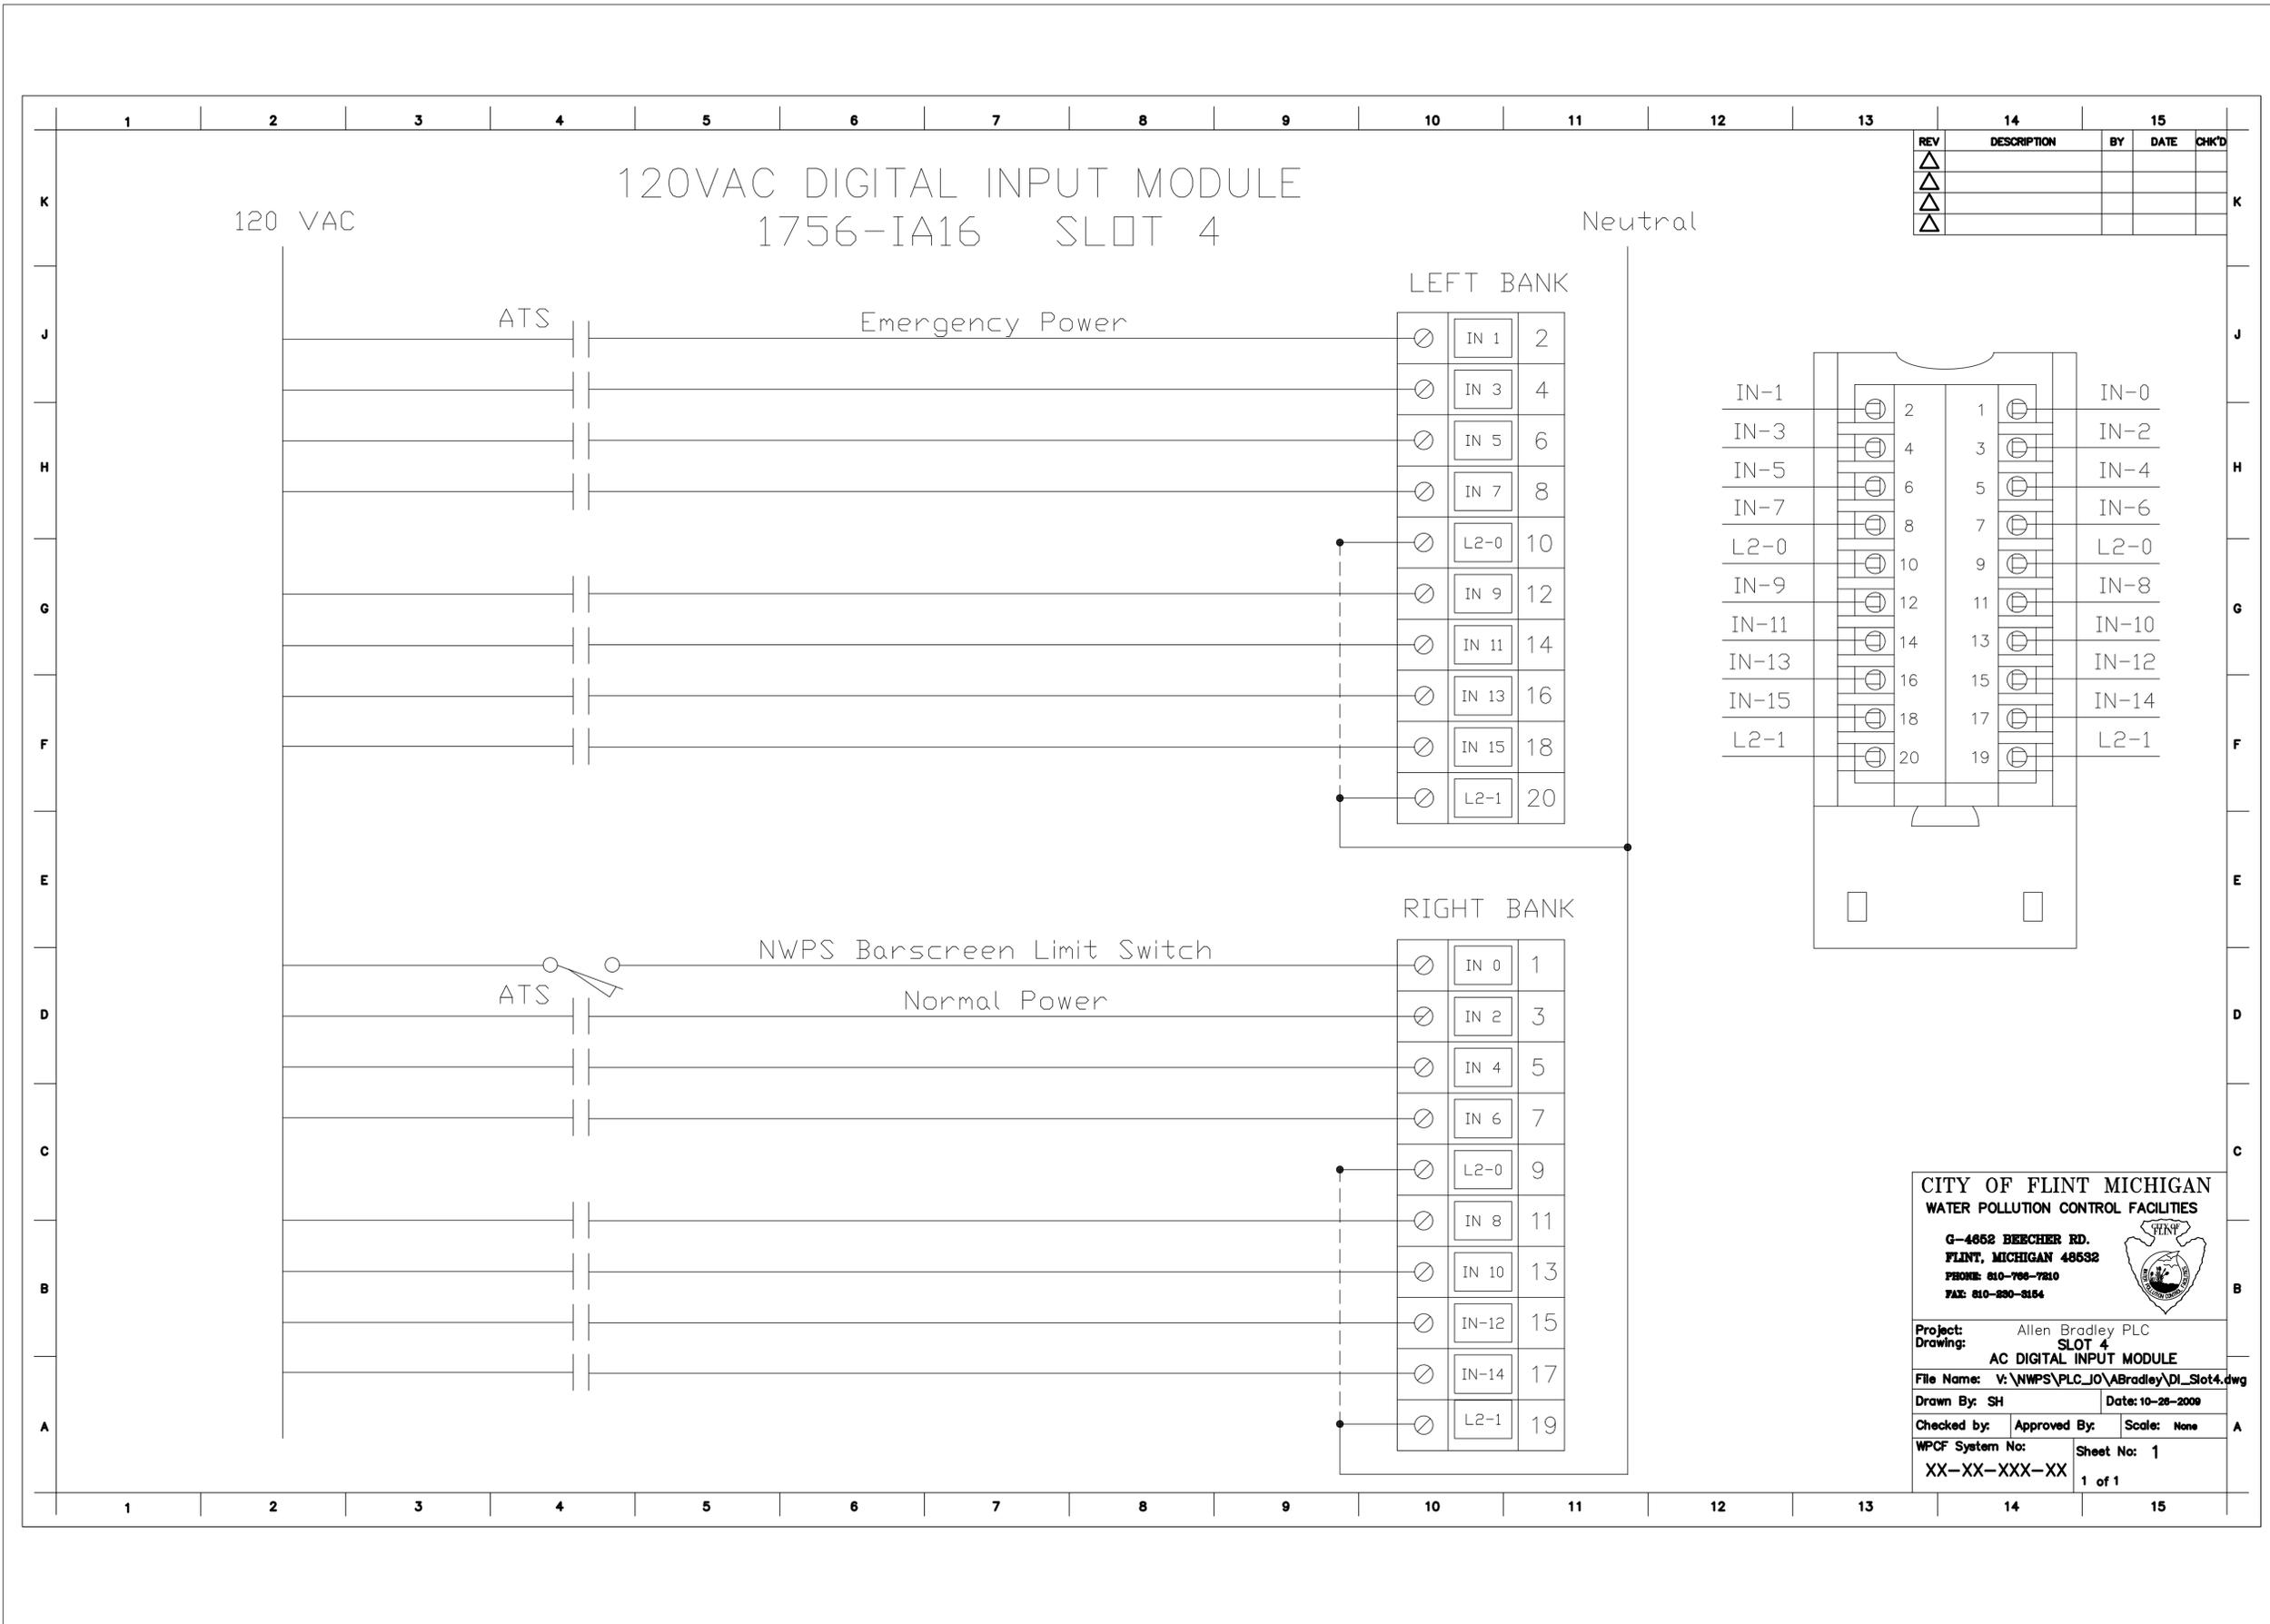

**CITY OF FLINT MICHIGAN
WATER POLLUTION CONTROL FACILITIES**

G-4852 BEECHER RD.
FLINT, MICHIGAN 48632
PHONE: 810-786-7210
FAX: 810-830-8154

Project: Allen Bradley PLC
 Drawing: SLOT 4
 AC DIGITAL INPUT MODULE
 File Name: V:\NWPS\PLC_I0\ABradley\DI_Slot4.dwg
 Drawn By: SH Date: 10-28-2009
 Checked by: Approved By: Scale: None
 WPCF System No: XX-XX-XXX-XX Sheet No: 1
 1 of 1

WARNING
 UTILITY LOCATIONS ARE NOT CONFIRMED. THOSE SHOWN WERE OBTAINED FROM THE CITY OF FLINT RECORDS. THE CONTRACTOR SHALL VERIFY ALL UTILITY LOCATIONS PRIOR TO BEGINNING WORK AND HE SHALL PROTECT OR HAVE RELOCATED, AS NOTED IN THE SPECIFICATIONS. ALL INTERFERENCE WITH CONSTRUCTION



City of Flint
 1101 S. Saginaw Street
 Flint, Michigan 48502

Northwest Pump Station Improvements
 Electrical Design

NOT TO SCALE

MARK	ISSUED FOR	DATE
-	EAGLE SUBMITTAL	2/14/2020
-		
-		
DRAWN BY: DLZ
 DESIGN BY: GJG
 CHECKED BY: GJG

DLZ JOB NUMBER: 1849-0706-00

SHEET NO.
E-103

DLZ
 ARCHITECTURE • ENGINEERING • PLANNING
 SURVEYING • CONSTRUCTION SERVICES


811
 3 FULL WORKING DAYS
 BEFORE YOU DIG CALL
 MISS DIG System, Inc.
 1-800-482-7171 www.missdig.net

Know what's below
 Call before you dig

INNOVATIVE IDEAS
 EXCEPTIONAL DESIGN
 UNMATCHED CLIENT SERVICE

SCALE: VERT. -
 HORZ.

Layout = E-104
 RUT DATE: 2/14/2020 1:53:48 PM
 BRENDAN WARBEL X:\Projects\WaterForAll\18500\18706_City of Flint Pump Station Rehabilitation\18706_Electrical.dwg

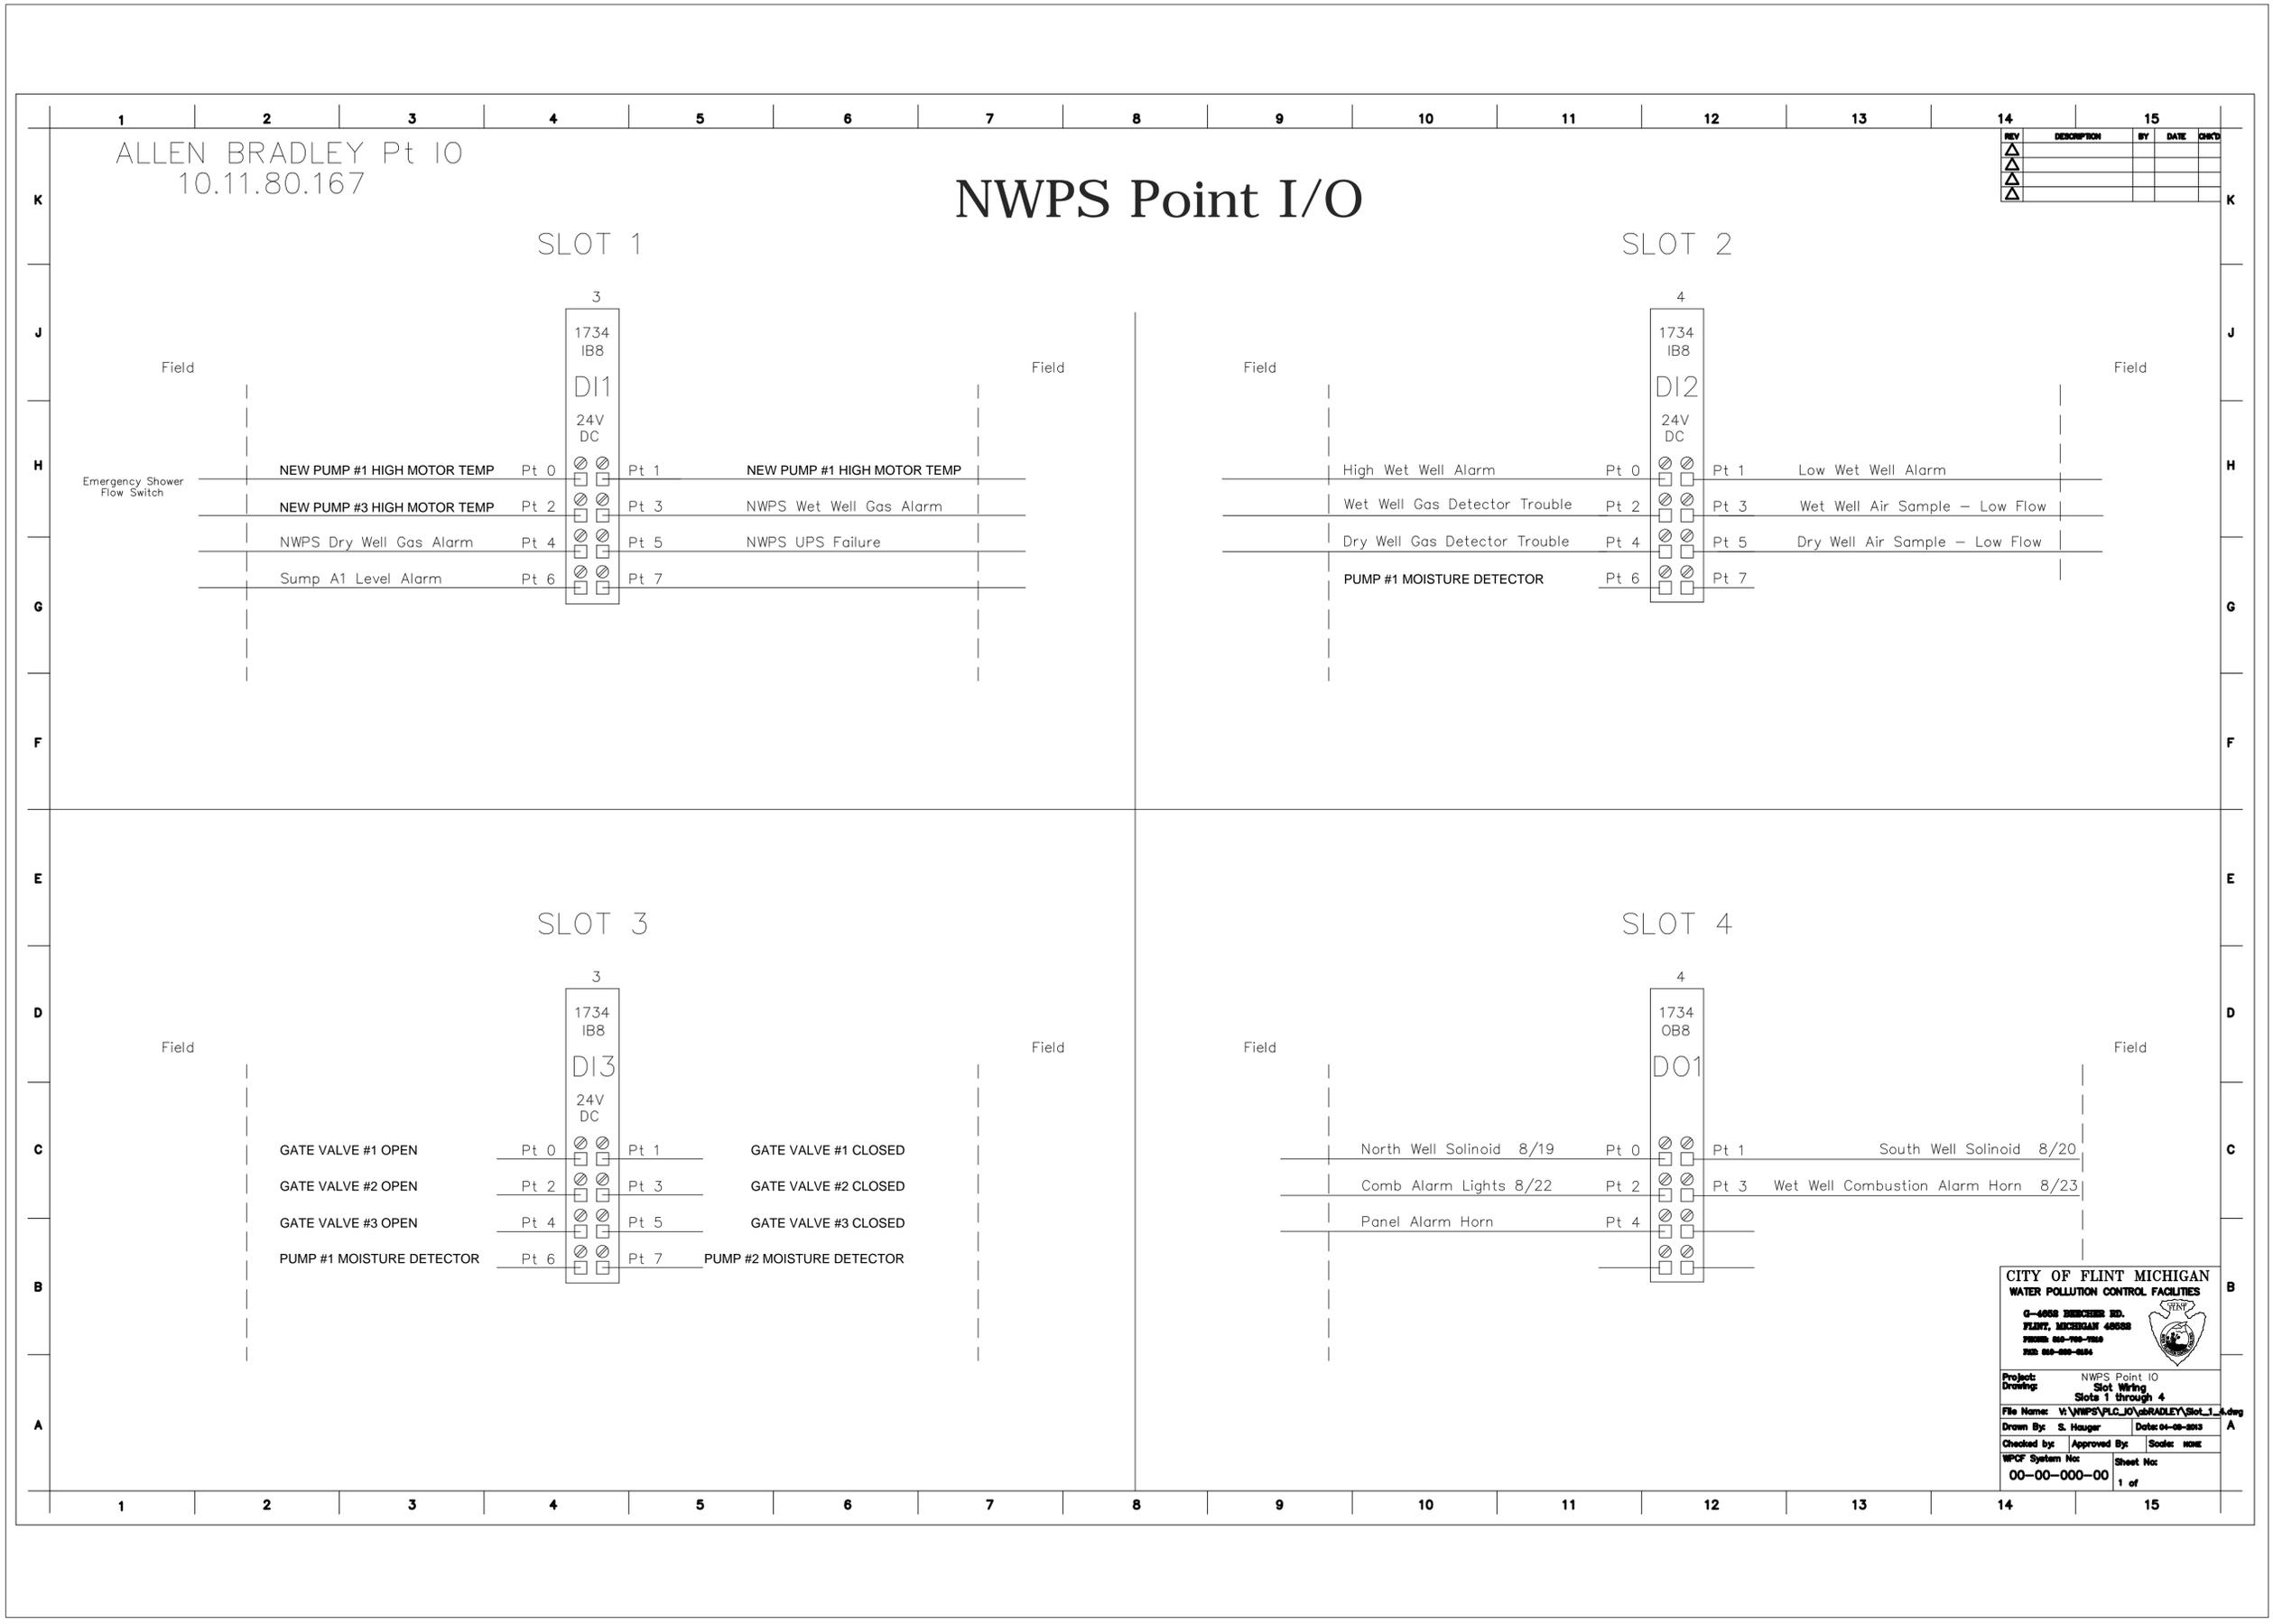

REV	DESCRIPTION	BY	DATE	CHKD

CITY OF FLINT MICHIGAN
WATER POLLUTION CONTROL FACILITIES

G-4608 SUBSISTERS RD.
FLINT, MICHIGAN 48908
PHONE: 810-798-7200
FAX: 810-798-2884

Project: NWPS Point IO
 Drawing: Slot Wiring
 Slots 1 through 4
 File Name: W:\NWPS\PLC_IO\ALLENBRADLEY\Slot_1.dwg
 Drawn By: S. Hauger Date: 01-08-2020
 Checked by: Approved By: Scale: NONE
 WPCF System No: 00-00-000-00 Sheet No: 1 of 1

UTILITY LOCATIONS ARE NOT CONFIRMED. THOSE SHOWN WERE OBTAINED FROM THE RECORD DRAWINGS. THE CONTRACTOR SHALL VERIFY THE LOCATION AND DEPTH OF ALL UTILITIES PRIOR TO BEGINNING WORK AND HE SHALL PROTECT OR HAVE RELOCATED, AS NOTED IN THE SPECIFICATIONS. ALL INTERFERENCE WITH CONSTRUCTION

WARNING

DLZ

ARCHITECTURE • ENGINEERING • PLANNING
SURVEYING • CONSTRUCTION SERVICES

City of Flint
 1101 S. Saginaw Street
 Flint, Michigan 48502

Northwest Pump Station Improvements
 Electrical Design

NOT TO SCALE

MARK	ISSUED FOR	DATE
-	EAGLE SUBMITTAL	2/14/2020
-		
-		
DRAWN BY: DLZ
 DESIGN BY: GJG
 CHECKED BY: GJG

DLZ JOB NUMBER: 1849-0706-00


SHEET NO. E-104

Know what's below
 811 BEFORE YOU DIG CALL
 MISS DIG System, Inc.
 1-800-482-7171 www.missdig.net

INNOVATIVE IDEAS
 EXCEPTIONAL DESIGN
 UNMATCHED CLIENT SERVICE

SCALE: VERT. -
HORZ.

Layout = E-105
 RUT DATE: 2/14/2020 1:53:33 PM
 BRENDAN WARBEL X:\Projects\Waterfor18500\18706 City of Flint Pump Station Rehabilitation\18706 Electrical.dwg

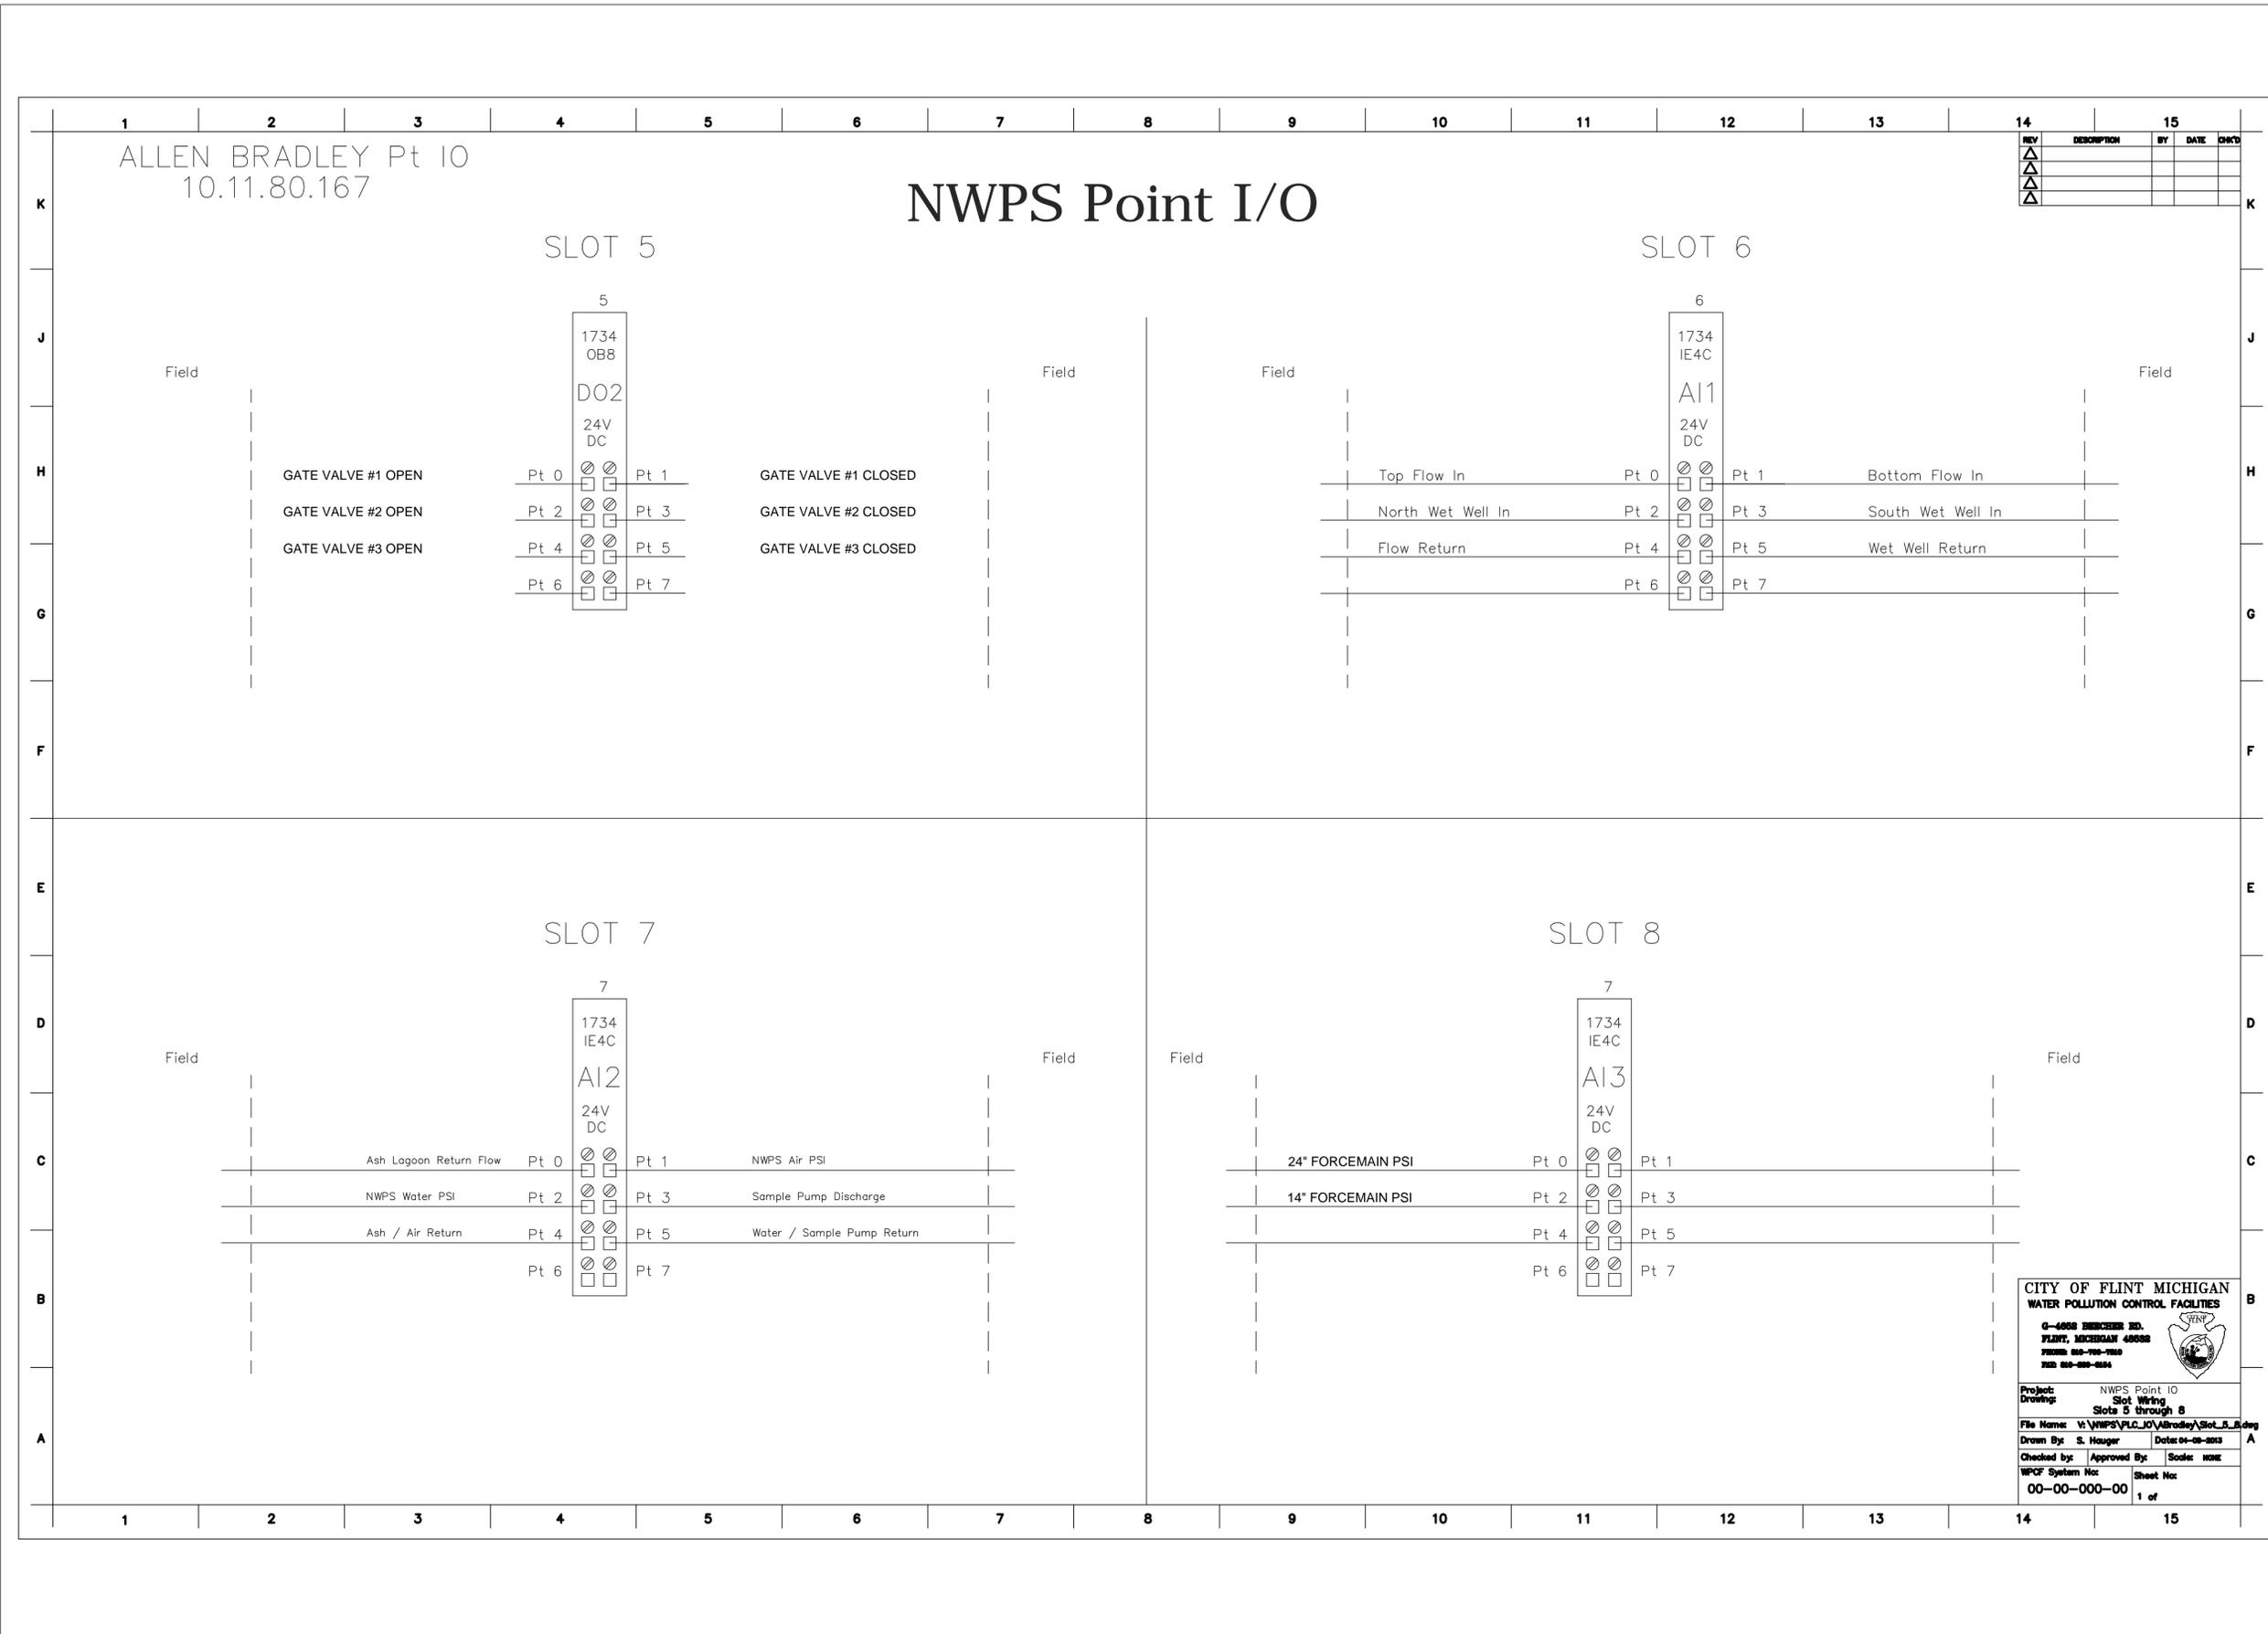

REV	DESCRIPTION	BY	DATE	CHKD

CITY OF FLINT MICHIGAN
WATER POLLUTION CONTROL FACILITIES

0-4608 BERCHER RD.
 FLINT, MICHIGAN 48908
 PHONE: 810-790-1100
 FAX: 810-790-0304

Project: NWPS Point IO
 Drawing: Slot Wiring
 Slots 5 through 8

File Name: V:\NWPS\PLC_IO\Bradley\Slot_5.dwg
 Drawn By: S. Hauger Date: 01-08-2013 A
 Checked by: Approved By: Scale: NONE
 WPCF System No: 00-00-000-00 Sheet No: 1 of 1

NOT TO SCALE

MARK	ISSUED FOR	DATE
-	EAGLE SUBMITTAL	2/14/2020
-		
-		
DRAWN BY: DLZ
 DESIGN BY: GJG
 CHECKED BY: GJG

DLZ JOB NUMBER: 1849-0706-00

SHEET NO.
E-105

WARNING
 UTILITY LOCATIONS ARE NOT CONFIRMED. THOSE SHOWN WERE OBTAINED FROM FIELD SURVEY. CONTRACTOR SHALL VERIFY ALL UTILITY LOCATIONS PRIOR TO BEGINNING WORK. THE CONTRACTOR SHALL BE RESPONSIBLE FOR PROTECTING ALL EXISTING UTILITIES AND SHALL PROTECT OR RELOCATE AS NOTED IN THE SPECIFICATIONS. ALL INTERFERENCE WITH CONSTRUCTION.

City of Flint
 1101 S. Saginaw Street
 Flint, Michigan 48502
 Northwest Pump Station Improvements
 Electrical Design


DLZ
 ARCHITECTURE • ENGINEERING • PLANNING
 SURVEYING • CONSTRUCTION SERVICES

INNOVATIVE IDEAS
 EXCEPTIONAL DESIGN
 UNMATCHED CLIENT SERVICE

Know what's below
 Call before you dig
811 BEFORE YOU DIG CALL
 MISS DIG System, Inc.
 1-800-482-7171 www.missdig.net

SCALE: VERT. -
HORIZ.


Layout = E-106
 RUT DATE: 2/14/2020 1:52:58 PM
 BRENDAN WARBEL \\N:\Projects\WaterforA18500\18706_City of Flint Pump Station Rehabilitation\18706_Electrical.dwg

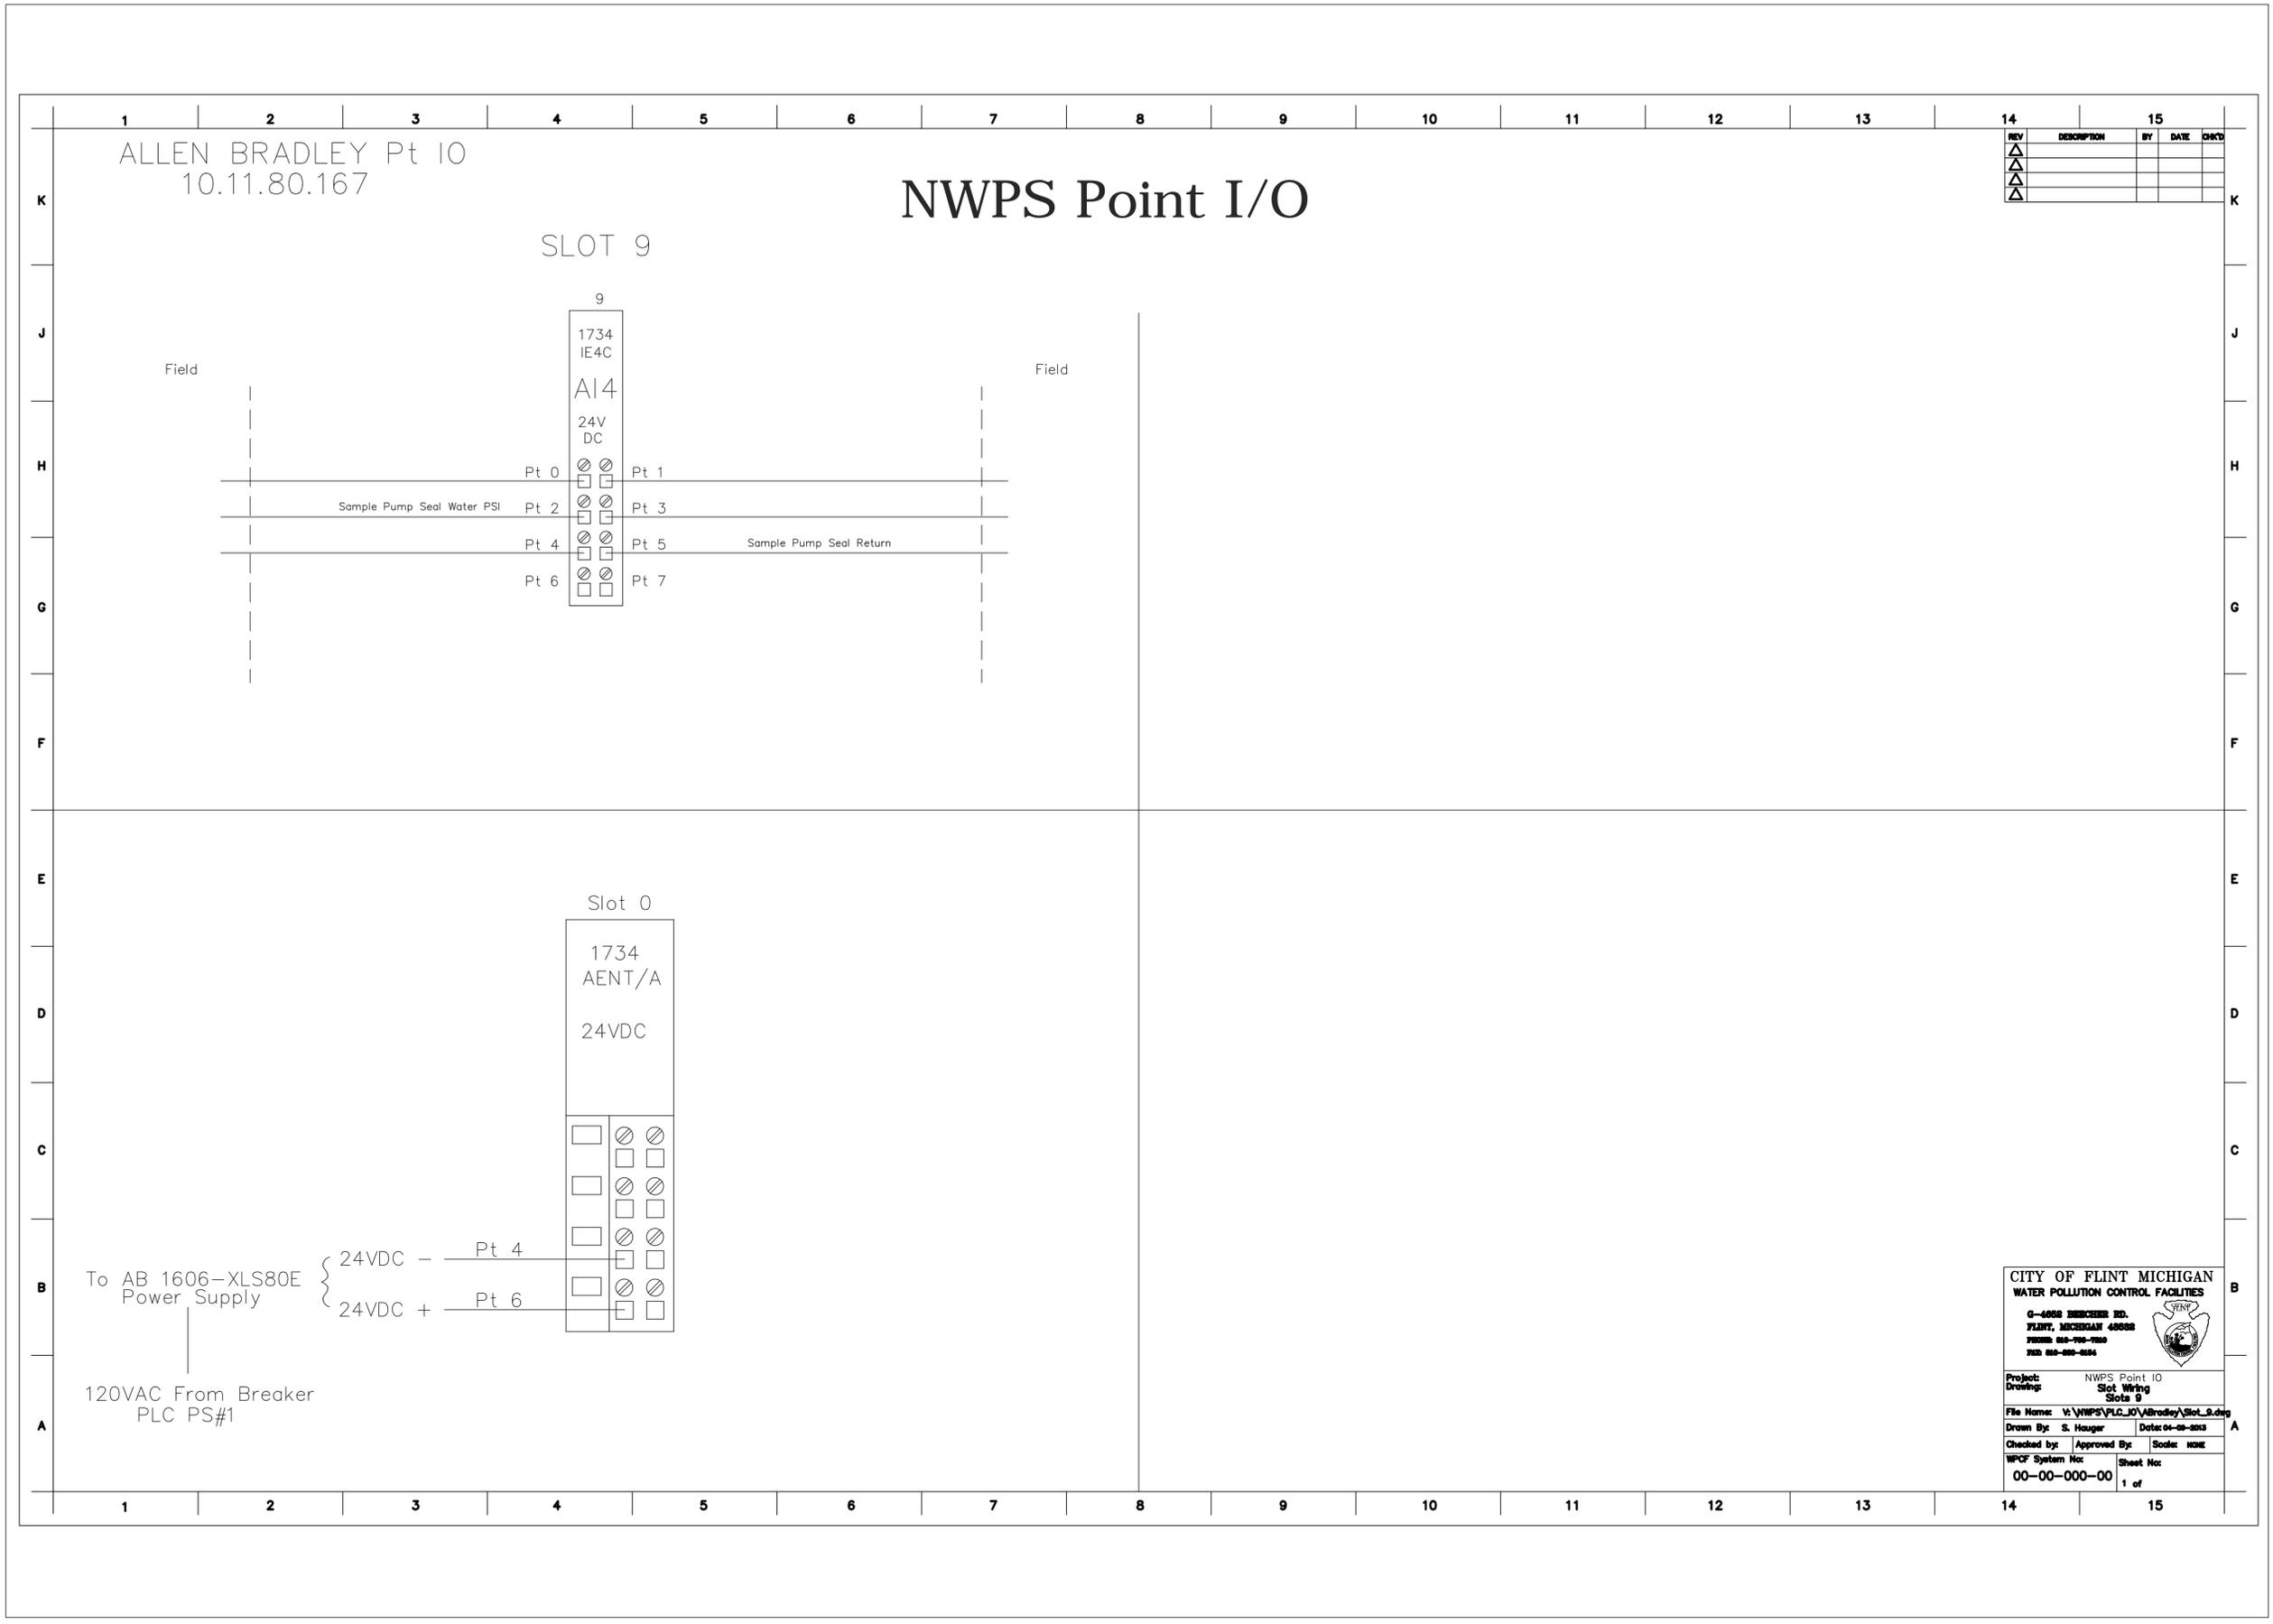



NWPS Point I/O

ALLEN BRADLEY Pt IO
10.11.80.167

SLOT 9

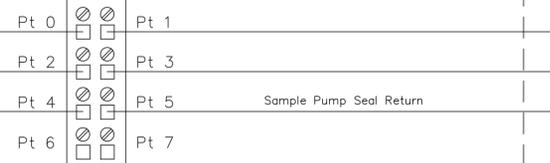

Slot 0

 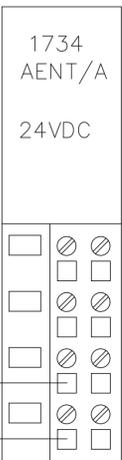

To AB 1606-XLS80E
Power Supply

120VAC From Breaker
PLC PS#1

REV	DESCRIPTION	BY	DATE	CHKD

CITY OF FLINT MICHIGAN
WATER POLLUTION CONTROL FACILITIES

G-4008 BREXESER RD.
 FLINT, MICHIGAN 48908
 PHONE: 810-226-7800
 FAX: 810-226-6164



Project: NWPS Point IO
 Drawings: Slot Wiring
 Slot 9

File Name: W:\NWPS\PLC_IO\Bradley\Slot_9.dwg
 Drawn By: S. Hauger Date: 04-08-2015
 Checked by: Approved By: Scale: NONE

WPCF System No: Sheet No:
 00-00-000-00 1 of 1

Know what's below
 Call before you dig
 MISS DIG System, Inc.
 1-800-482-7171 www.missdig.net

811
 3 FULL WORKING DAYS
 BEFORE YOU DIG CALL

DLZ
 ARCHITECTURE • ENGINEERING • PLANNING
 SURVEYING • CONSTRUCTION SERVICES

INNOVATIVE IDEAS
 EXCEPTIONAL DESIGN
 UNMATCHED CLIENT SERVICE

WARNING
 UTILITY LOCATIONS ARE NOT
 CONFIRMED. THOSE SHOWN
 WERE OBTAINED FROM
 MISS DIG SYSTEM, INC.
 THREE FULL WORKING DAYS
 PRIOR TO BEGINNING WORK.
 THE CONTRACTOR SHALL
 VERIFY ALL LOCATIONS AND
 HAVE WORK AREA STAKED
 AND HE SHALL PROTECT OR
 HAVE RELOCATED, AS NOTED
 IN THE SPECIFICATIONS. ALL
 INTERFERENCE WITH
 CONSTRUCTION



City of Flint
 1101 S. Saginaw Street
 Flint, Michigan 48502

Northwest Pump Station Improvements
 Electrical Design

NOT TO SCALE

MARK	ISSUED FOR	DATE
-	EAGLE SUBMITTAL	2/14/2020
-	-	-
-	-	-

DRAWN BY: DLZ
 DESIGN BY: GJG
 CHECKED BY: GJG

DLZ JOB NUMBER: 1849-0706-00

SHEET NO.
E-106

SCALE: VERT. -
 HORZ. -

Layout: E-108
 RUT DATE: 2/14/2020 1:54:08 PM
 BRENDAN WARBEL X:\Projects\Waterfor18500\18706 City of Flint Pump Station Rehabilitation\18706 Electrical.dwg

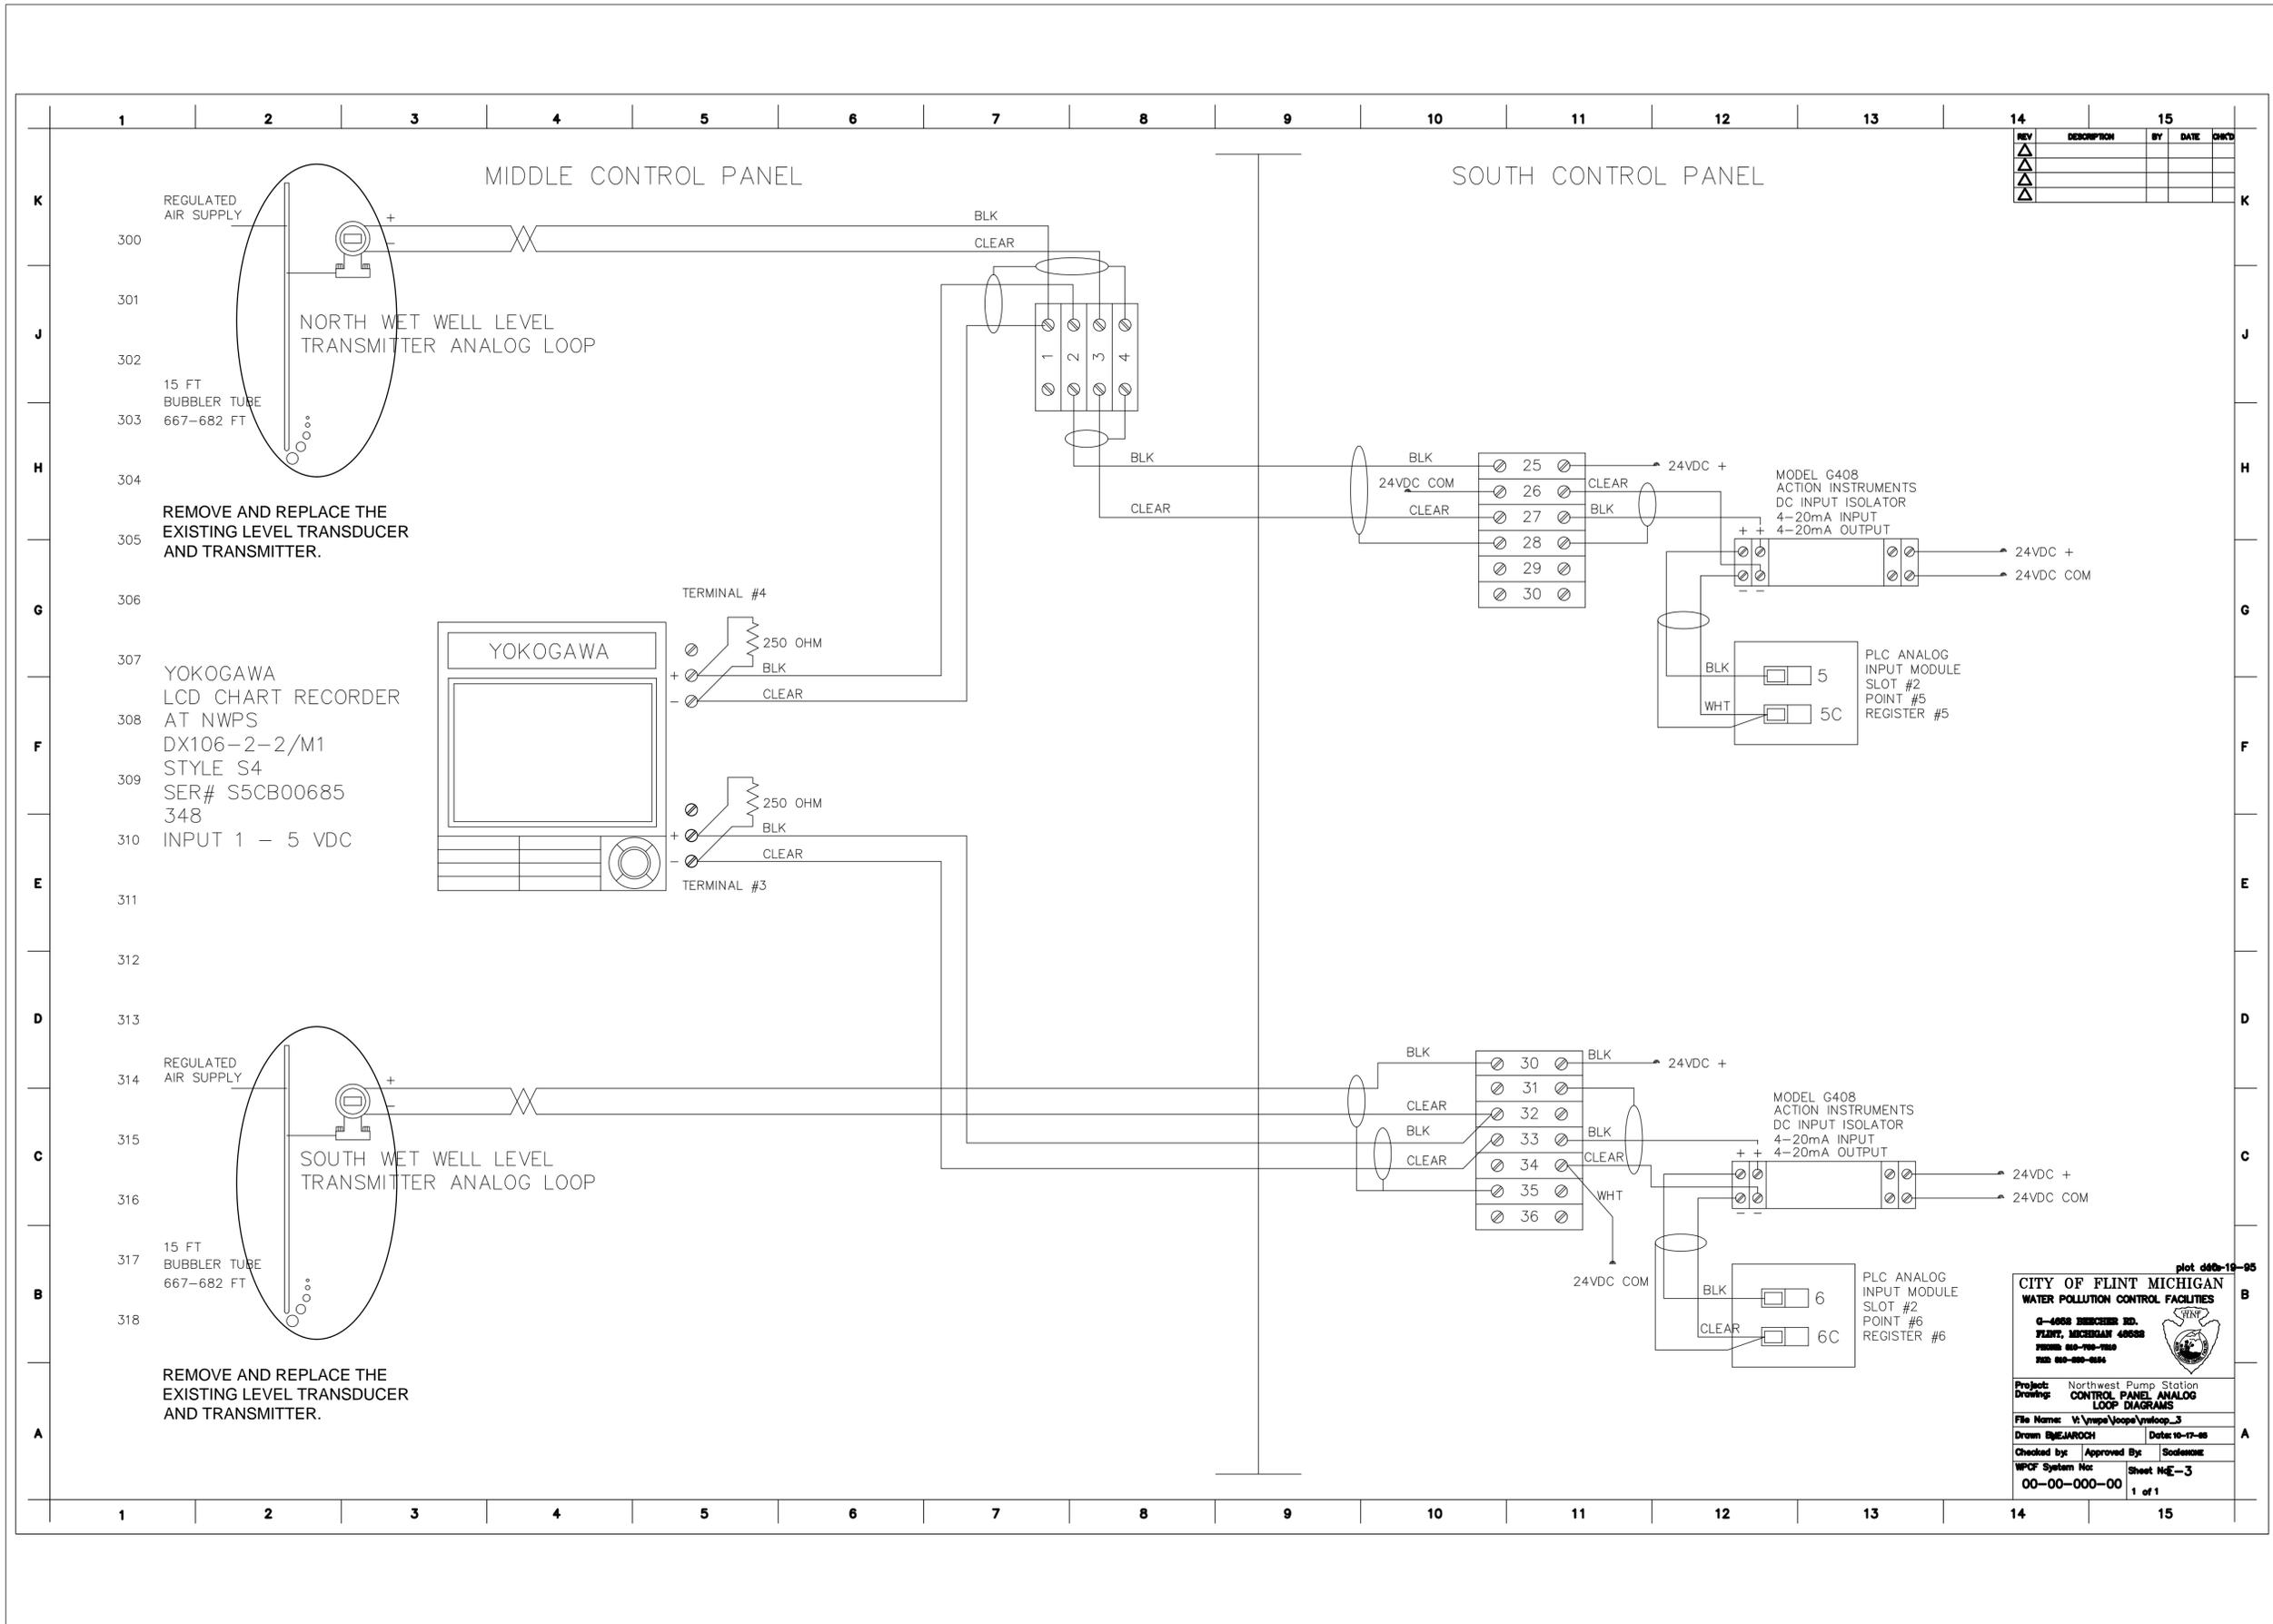

REV	DESCRIPTION	BY	DATE	CHKD

REMOVE AND REPLACE THE EXISTING LEVEL TRANSDUCER AND TRANSMITTER.

REMOVE AND REPLACE THE EXISTING LEVEL TRANSDUCER AND TRANSMITTER.

plot 060-18-05

CITY OF FLINT MICHIGAN
WATER POLLUTION CONTROL FACILITIES

0-4658 SHEET NO.
 FLINT, MICHIGAN 48908
 PHONE 810-799-7200
 FAX 810-882-2894

Project: Northwest Pump Station
Drawing: CONTROL PANEL ANALOG LOOP DIAGRAMS

File Name: Y:\mwp\loop\loop_3
Drawn: BRENDAN WARBEL **Date:** 10-17-20

Checked by: Approved By: **Socikowicz**

WPCF System No: 00-00-000-00 **Sheet No:** 3
 1 of 1

Know what's below
 Call before you dig
 MISS DIG System, Inc.
 1-800-482-7171 www.missdig.net

811
 3 FULL WORKING DAYS
 BEFORE YOU DIG CALL

DLZ
 ARCHITECTURE • ENGINEERING • PLANNING
 SURVEYING • CONSTRUCTION SERVICES

INNOVATIVE IDEAS
 EXCEPTIONAL DESIGN
 UNMATCHED CLIENT SERVICE

WARNING
 UTILITY LOCATIONS ARE NOT CONFIRMED. THOSE SHOWN WERE OBTAINED FROM MISS DIG SYSTEM, INC. PRIOR TO BEGINNING WORK. THE CONTRACTOR SHALL VERIFY ALL UTILITY LOCATIONS AND HAVE WORK AREA STAKED AND HE SHALL PROTECT OR HAVE RELOCATED, AS NOTED IN THE SPECIFICATIONS. ALL INTERFERE WITH CONSTRUCTION.

CITY OF FLINT

City of Flint
 1101 S. Saginaw Street
 Flint, Michigan 48502

Northwest Pump Station Improvements
 Electrical Design

NOT TO SCALE

MARK	ISSUED FOR	DATE
-	EAGLE SUBMITTAL	2/14/2020
-	-	-
-	-	-
MARK	ISSUED FOR	DATE
-	EAGLE SUBMITTAL	2/14/2020
-	-	-
-	-	-
DRAWN BY: DLZ
 DESIGN BY: GJG
 CHECKED BY: GJG

DLZ JOB NUMBER: 1849-0706-00

SHEET NO.
E-108

SCALE: VERT. -
 HORZ.